



LET'S VISUALISE YOUR DREAMS

ARCHITUCTURE PROJECT BY SKART DESIGN STUDIO

Mr. Muatafa 20 Marla

OUR VISION

At SKART Design Studio, we believe design is not a luxury for the few but a right for everyone. Our mission is to overcome cost and complexity by offering smart, efficient, and creative solutions that every family can cherish—empowering people with spaces of comfort, pride, and happiness.

ARCHITUCTURE

INTERIOR DESIGN EXTERIOR DESIGN







	SCHEDULE LIST
01	LIST
02	3D FRONT VIEW
03	TITLE PAGE LAYOUTS PLANS
04	GROUND FLOOR LAYOUT PLAN
05	FIRST FLOOR LAYOUT PLAN
06	MUMTY FLOOR LAYOUT PLAN
07	SITE PLAN
08	TITLE PAGE FURNITURE LAYOUT PLANS
09	GROUND FLOOR FURNITURE LAYOUT PLAN
10	FIRST FLOOR FURNITURE LAYOUT PLAN
11	MUMTY FLOOR FURNITURE LAYOUT PLAN
12	FRONT ELEVATION
13	SECTION A-A'
14	SECTION
15	TITLE PAGE DIMENSION PLANS & ELEVATIONS
16	GROUND FLOOR DIMENSION LAYOUT PLAN
17	FIRST FLOOR DIMENSION LAYOUT PLAN
18	MUMTY FLOOR DIMENSION LAYOUT PLAN
19	DIMENSION FRONT ELEVATION
20	TITLE PAGE DOOR & WINDOW SCHEDULES
21	GROUND FLOOR DOOR & WINDOW SCHEDULE
22	FIRST FLOOR DOOR & WINDOW SCHEDULE
23	MUMTY FLOOR DOOR & WINDOW SCHEDULE
24	LEGEND OF DOOR & WINDOW SCHEDULE
25	TITLE PAGE ELECTRICAL LAYOUT PLANS
26	GROUND FLOOR ELECTRICAL LAYOUT PLAN
27	FIRST FLOOR ELECTRICAL LAYOUT PLAN
28	MUMTY FLOOR ELECTRICAL LAYOUT PLAN
29	ELECTRICAL LEGENDS
30	TITLE PAGE PUBLIC HEALTH LAYOUT PLANS
31	GROUND FLOOR PUBLIC HEALTH LAYOUT PLAN
32	FIRST FLOOR PUBLIC HEALTH LAYOUT PLAN
33	MUMTY FLOOR PUBLIC HEALTH LAYOUT PLAN
34	SANITATION LEGENDS
35	SEPTIC TANK DETAILS
36	TITLE PAGE PLUMBRING LAYOUT PLANS
37	GROUND FLOOR PLUMBRING LAYOUT PLAN
38	FIRST FLOOR PLUMBRING LAYOUT PLAN
39	MUMTY FLOOR PLUMBRING LAYOUT PLAN
40	PLUMBRING LEGENDS
41	O.H.W.TANK DETAILS
42	STRUCTURE DETAILS



PROJECT TITLE:

Mr. MUSTAFA Residential Architecture Plan.



SKART DESIGN STUDIO

LET'S VISUALISE YOUR DREAM ARCHITECTURE, INTERIOR DESIGN WOOD WORKS Voice:

E-mail: Skart.design.studio@gmail.com

Address: Office # 01, Devis Road Habibullah Street, Near Durand Rd, Lahore, Pakistan.

THESE DRAWINGS REMAIN THE PROPERTY OF SKART Design Studio ANY REPRODUCTION WILL CONSIDERED TO BE UNLAWFUL. ELECTRICAL CONSULTANT:

SKART DESIGN STUDIO

STRUCTURAL CONSULTANT:

SKART DESIGN STUDIO

PUBLIC HEALTH CONSULTANT:

SKART DESIGN STUDIO

DESIGN PROPOSAL

NOTES:

SKART DESIGN STILLD DOES NOT PROVIDE A
GRINDA FLOR LATOUT LANK FOR EXCLATION
AND FOLNDATION ON STE.
 SKART DESIGN STILLD ISSUED A GROUND FLOOR
PLAN FOR EXCLATION AND FOUNDATION ON-STE
AS ENE CONTRACTOR AND FLOOR BUILDING DISSUED
SKART DESIGN STILLD GROWN OF THE START OF

FOR STARTING CONSTRUCTION WORK ON SI

SKART DESIGN STUDIO WILL, NOT BE
RESPONSIBLE IN CASE OF ANY VARIATION
MISTAKE ON-SITE AT THE TIME OF CONSTI

 IN CASE OF ANY KIND OF MISTAKE OR DIFFERE IN SIZES IN THE FOUNDATION AND EXCAVATION DURING CONSTRUCTION, THE SITE WILL NOT BE

Drawn by: Ar.Tasneem
Designed by: Ar.Tasneem

D No: A-201 Scole: AS SHOWN DATE: 10-01-2025 REVISED DATE: 00-00-2025 REVISION NO: 00

Sheet Tit

3D FRONT VIEW

Original drawing is A3. Scale entitles accordingly if reduced Sheet Number:

LAYOUT LANS

PROJECT TITLE: Mr. MUSTAFA Residential

Architecture Plan.



SKART DESIGN STUDIO

LET'S VISUALISE YOUR DREAM ARCHITECTURE , INTERIOR DESIGN WOOD WORKS

Voice: +92 313 5734471

F-mail: Skart.design.studio@gmail.com

Address: Office # 01, Devis Road Habibullah Street. Near Durand Rd. Lahore.

THESE DRAWINGS REMAIN THE PROPERTY OF SKART Design Studio ANY REPRODUCTION WILL CONSIDERED TO BE UNLAWFUL. ELECTRICAL CONSULTANT:

SKART DESIGN STUDIO

STRUCTURAL CONSULTANT:

SKART DESIGN STUDIO

PUBLIC HEALTH CONSULTANT:

SKART DESIGN STUDIO

DESIGN PROPOSAL


NOTES:

Drawn by: Ar.Tasneem Designed by: Ar. Tasneem

ID No: A-201 Scale: AS SHOWN DATE: 10-01-2025 REVISED DATE: 00-00-2025 REVISION NO: 00

TITLE PAGE LAYOUT PLAN

Original drawing is A3. Scale entities accordingly if reduced

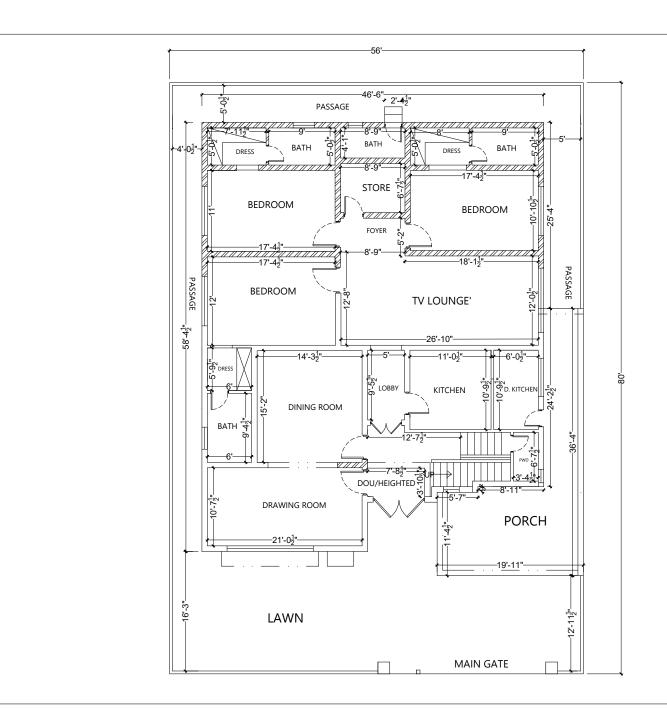



SKART DESIGN STUDIO

LET'S VISUALISE YOUR DREAM ARCHITECTURE , INTERIOR DESIGN WOOD WORKS

Voice: +92 313 5734471

E-mail: Skart.design.studio@gmail.com

Address: Office # 01, Devis Road Habibullah Street, Near Durand Rd, Lahore, Pakistan.

THESE DRAWINGS REMAIN THE PROPERTY OF SKART Design Studio ANY REPRODUCTION WILL CONSIDERED TO BE UNLAWFUL. ELECTRICAL CONSULTANT:

SKART DESIGN STUDIO

STRUCTURAL CONSULTANT:

SKART DESIGN STUDIO

PUBLIC HEALTH CONSULTANT:

SKART DESIGN STUDIO

DESIGN PROPOSAL


NOTES:

Designed by: Ar Tasneem

ID No: Scale: DATE: A-201 AS SHOWN 10-01-2025 REVISED DATE: 00-00-2025 REVISION NO: 00

GROUND FLOOR LAYOUT PLAN

Original drawing is A3. Scale entitles accordingly if reduced Sheet Number:

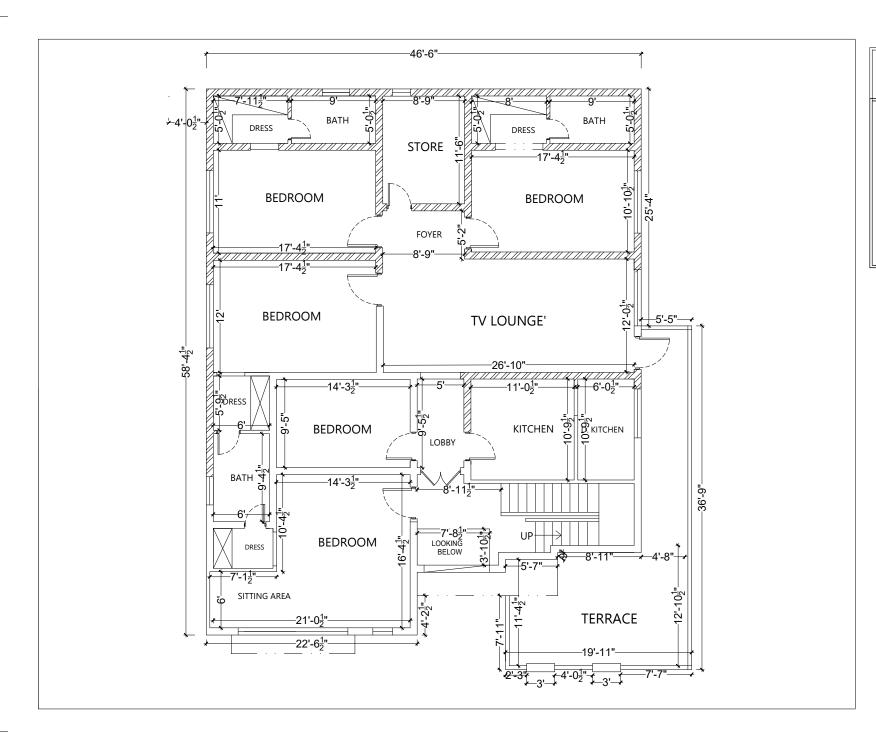



SKART DESIGN STUDIO

LET'S VISUALISE YOUR DREAM ARCHITECTURE , INTERIOR DESIGN WOOD WORKS

Voice: +92 313 5734471

E-mail: Skart.design.studio@gmail.com

Address: Office #01, Devis Road Habibullah Street, Near Durand Rd, Lahore, Pakistan.

THESE DRAWINGS REMAIN THE PROPERTY OF SKART Design Studio ELECTRICAL CONSULTANT:

SKART DESIGN STUDIO

STRUCTURAL CONSULTANT:

SKART DESIGN STUDIO

PUBLIC HEALTH CONSULTANT:

SKART DESIGN STUDIO

DESIGN PROPOSAL


NOTES:

Designed by: Ar Tasneem

ID No: Scale: DATE: A-201 AS SHOWN 10-01-2025 REVISED DATE: 00-00-2025 REVISION NO: 00

FIRST FLOOR LAYOUT PLAN

Original drawing is A3. Scale entitles accordingly if reduced Sheet Number:

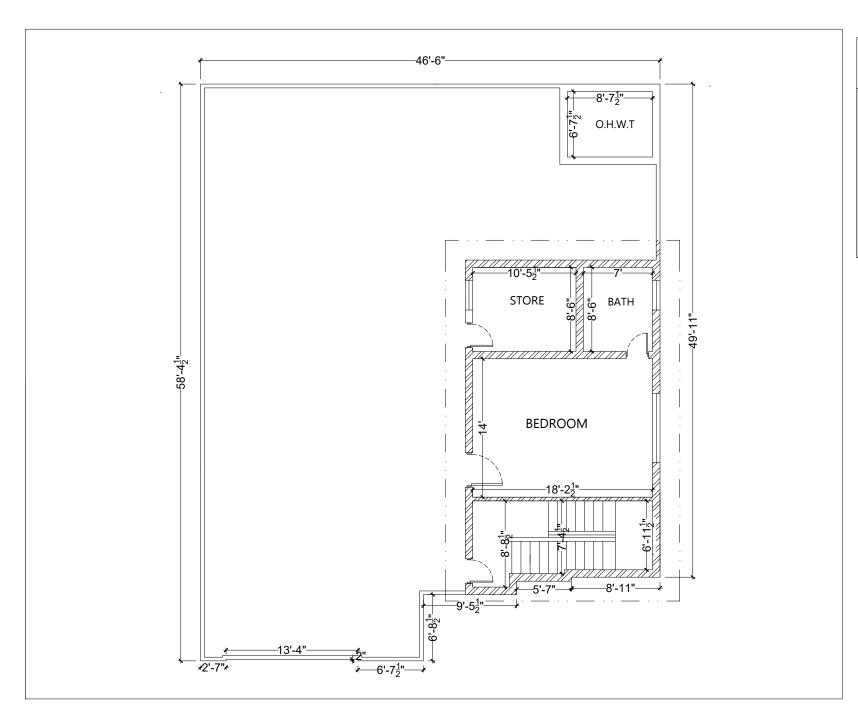

PROJECT TITLE: Mr. MUSTAFA Residential



SKART DESIGN STUDIO

LET'S VISUALISE YOUR DREAM ARCHITECTURE, INTERIOR DESIGN WOOD WORKS

Voice: +92 313 5734471

E-mail: Skart.design.studio@gmail.com

Address: Office # 01, Devis Road Habibullah Street, Near Durand Rd, Lahore, Pakistan.

THESE DRAWINGS REMAIN THE PROPERTY OF SKART Design Studio ANY REPRODUCTION WILL CONSIDERED TO BE UNLAWFUL. ELECTRICAL CONSULTANT:

SKART DESIGN STUDIO

STRUCTURAL CONSULTANT:

SKART DESIGN STUDIO

PUBLIC HEALTH CONSULTANT:

SKART DESIGN STUDIO

DESIGN PROPOSAL


NOTES:

Drawn by: Ar.Tasneem Designed by: Ar.Tasneem

ID No: A-201 Scale: AS SHOWN DATE: 10-01-2025 REVISED DATE: 00-00-2025 REVISION NO: 00

MUMTY FLOOR LAYOUT PLAN

Original drawing is A3. Scale entities accordingly if reduced Sheet Number:

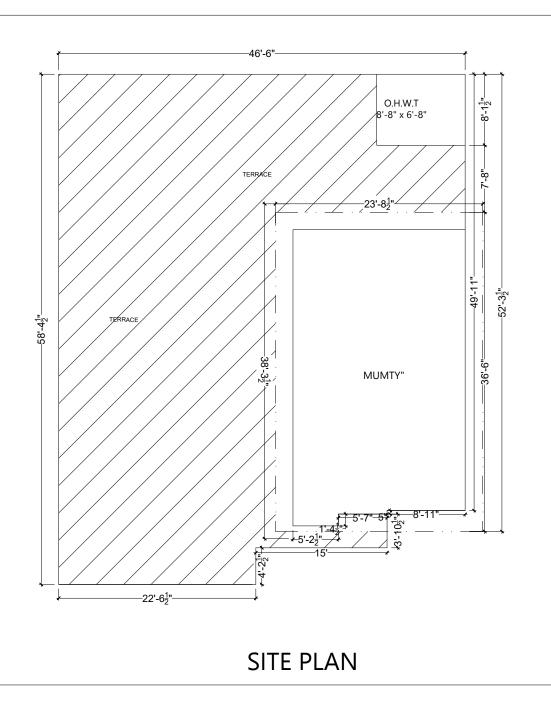



SKART DESIGN STUDIO

LET'S VISUALISE YOUR DREAM ARCHITECTURE , INTERIOR DESIGN WOOD WORKS

Voice: +92 313 5734471 E-mail: Skart.design.studio@gmail.com

Address: Office # 01, Devis Road Habibullah Street, Near Durand Rd, Lahore, Pakistan.

THESE DRAWINGS REMAIN THE PROPERTY OF SKART Design Studio ANY REPRODUCTION WILL CONSIDERED TO BE UNLAWFUL. ELECTRICAL CONSULTANT:

SKART DESIGN STUDIO

STRUCTURAL CONSULTANT:

SKART DESIGN STUDIO

PUBLIC HEALTH CONSULTANT:

SKART DESIGN STUDIO

DESIGN PROPOSAL

NOTES:

Drawn by: Ar.Tasneem Designed by: Ar.Tasneem

ID No: A-201 Scale: AS SHOWN DATE: 10-01-2025 REVISED DATE: 00-00-2025 REVISION NO: 00

SITE PLAN

Original drawing is A3. Scale entitles accordingly if reduced Sheet Number:

FURNITURE LAYOUT PLANS

PROJECT TITLE:
Mr. MUSTAFA
Residential

Architecture Plan.



SKART DESIGN STUDIO

LET'S VISUALISE YOUR DREAM ARCHITECTURE, INTERIOR DESIGN

> Voice: +92 313 5734471

E-mail: Skart.design.studio@gmail.com

Address: Office # 01, Devis Road Habibullah Street, Near Durand Rd, Lahore, Pakistan.

THESE DRAWINGS REMAIN THE PROPERTY OF SKART Design Studio
ANY REPRODUCTION WILL CONSIDERED TO BE UNLAWFUL.

ELECTRICAL CONSULTANT:

SKART DESIGN STUDIO

STRUCTURAL CONSULTANT:

SKART DESIGN STUDIO

PUBLIC HEALTH CONSULTANT:

SKART DESIGN STUDIO

DESIGN PROPOSAL

NOTES:

SKART DESIGN STUDIO DOES NOT PROVIDE A

AND FOUNDATION ON SITE.

SKAPT Design Stilling ISSUED a ground Eld

PLAN FOR EXCAVATION AND FOUNDATION ON-SI

 SKART DESIGN STUDIO ONLY PROVIDES TH EXCAVATION AND FOUNDATION DETAILED PI

FOR STARTING CONSTRUCTION WORK ON SIT

SKART DESIGN STUDIO WILL NOT BE

MISTAKE ON-SITE AT THE TIME OF CONSTR
 IN CASE OF ANY KIND OF MISTAKE OR DIFF.

IN CASE OF ANY KIND OF MISTAKE OR DIFF
 IN SIZES IN THE FOUNDATION AND EXCAVA

DURING CONSTRUCTION, THE SITE WILL NOT B

APPROVED BY THE ARCHITECT.


Drawn by: Ar.Tasneem
Designed by: Ar.Tasneem

ID No: A-201 Sodie: AS SHOWN DATE: 10-01-2025 REVISED DATE: 00-00-2025 REVISION NO: 00

Shee

TITLE PAGE FURNITURE LAYOUTS PLAN

Original drawing is A3. Scale entities accordingly if reduced

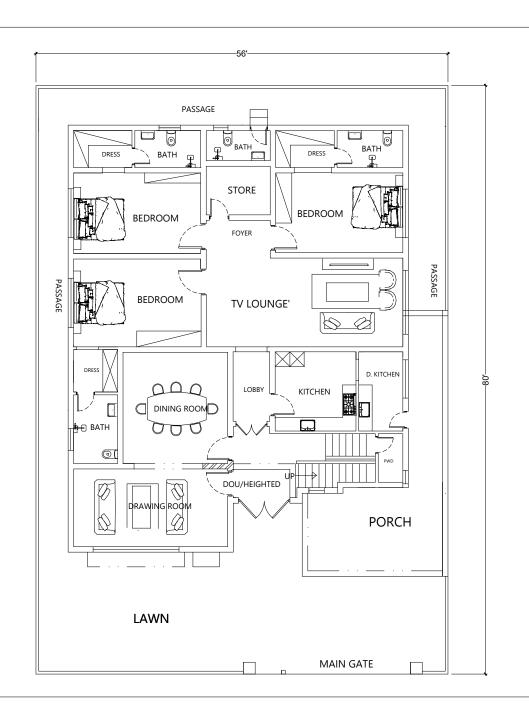



SKART DESIGN STUDIO

LET'S VISUALISE YOUR DREAM ARCHITECTURE , INTERIOR DESIGN WOOD WORKS Voice: +92 313 5734471

E-mail: Skart.design.studio@gmail.com

Address: Office # 01, Devis Road Habibullah Street, Near Durand Rd, Lahore, Pakistan.

THESE DRAWINGS REMAIN THE PROPERTY OF SKART Design Studio ANY REPRODUCTION WILL CONSIDERED TO BE UNLAWFUL. ELECTRICAL CONSULTANT:

SKART DESIGN STUDIO

STRUCTURAL CONSULTANT:

SKART DESIGN STUDIO

PUBLIC HEALTH CONSULTANT:

SKART DESIGN STUDIO

DESIGN PROPOSAL


NOTES:

Designed by: Ar.Tasneem

ID No: Scale: DATE: A-201 AS SHOWN 10-01-2025 REVISED DATE: 00-00-2025 REVISION NO: 00

GROUND FLOOR FURNITURE LAYOUT PLAN

Original drawing is A3. Scale entities accordingly if reduced Sheet Number:

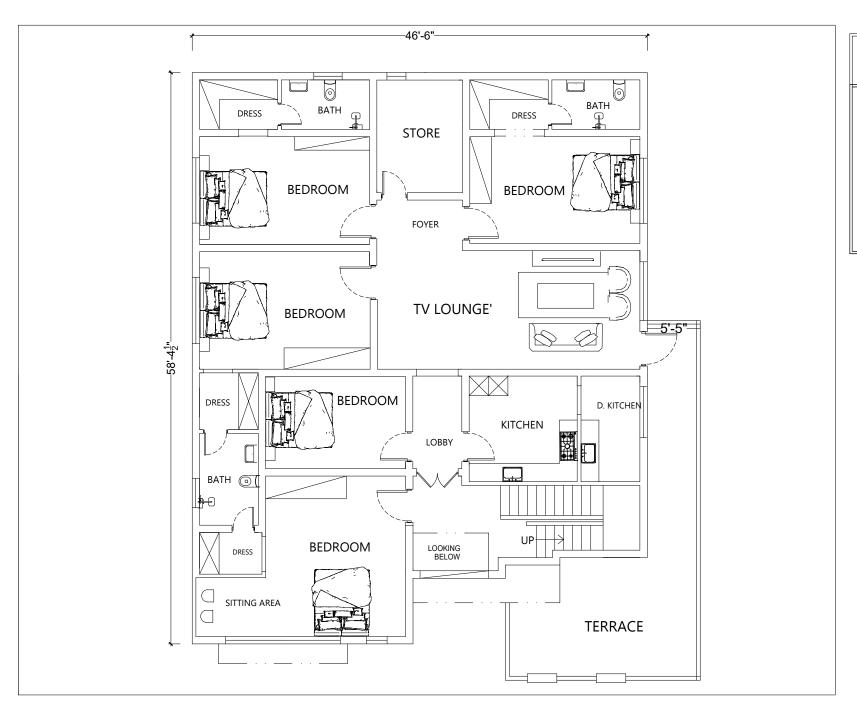



SKART DESIGN STUDIO

LET'S VISUALISE YOUR DREAM ARCHITECTURE, INTERIOR DESIGN WOOD WORKS

Voice: +92 313 5734471

E-mail: Skart.design.studio@gmail.com

Address: Office # 01, Devis Road Habibullah Street, Near Durand Rd, Lahore, Pakistan.

THESE DRAWINGS REMAIN THE PROPERTY OF SKART Design Studio MY REPRODUCTION WILL CONSIDERED TO BE UNLAWFUL.

ELECTRICAL CONSULTANT:

SKART DESIGN STUDIO

STRUCTURAL CONSULTANT:

SKART DESIGN STUDIO

PUBLIC HEALTH CONSULTANT:

SKART DESIGN STUDIO

DESIGN PROPOSAL

NOTES:

SKART DESIGN STUDIO DOES NOT PROVIDE A

GROUND FLOOR LAYOUT PLAN FOR EXCAVATION AND FOUNDATION ON SITE.

 SKART DESIGN STUDIO ISSUED A GROUND FLO PLAN FOR EXCAVATION AND FOUNDATION ON-S

SKART DESIGN STUDIO ONLY PROVIDES THE

FOR STARTING CONSTRUCTION WORK ON SITE

 SKART DESIGN STUDIO WILL NOT BE RESPONSIBLE IN CASE OF ANY VARIATION OR

MISTAKE ON-SITE AT THE TIME OF CONSTRU

IN CASE OF ANY KIND OF MISTAKE OR DIFFER

IN SIZES IN THE FOUNDATION AND EXCAVATION PROPERTY OF THE SIZE WILL MOST BE

DURING CONSTRUCTION, THE SITE WILL NOT E APPROVED BY THE ARCHITECT.

Drawn by: Ar.Tasneem
Designed by: Ar.Tasneem

ID No: A-201
Scale: AS SHOWN

DATE: 10-01-2025


REVISED DATE: 00-00-2025

REVISION NO: 00

Sheet Title

FIRST FLOOR FURNITURE LAYOUT PLAN

Original drawing is A3. Scale entities accordingly if reduced Sheet Number:

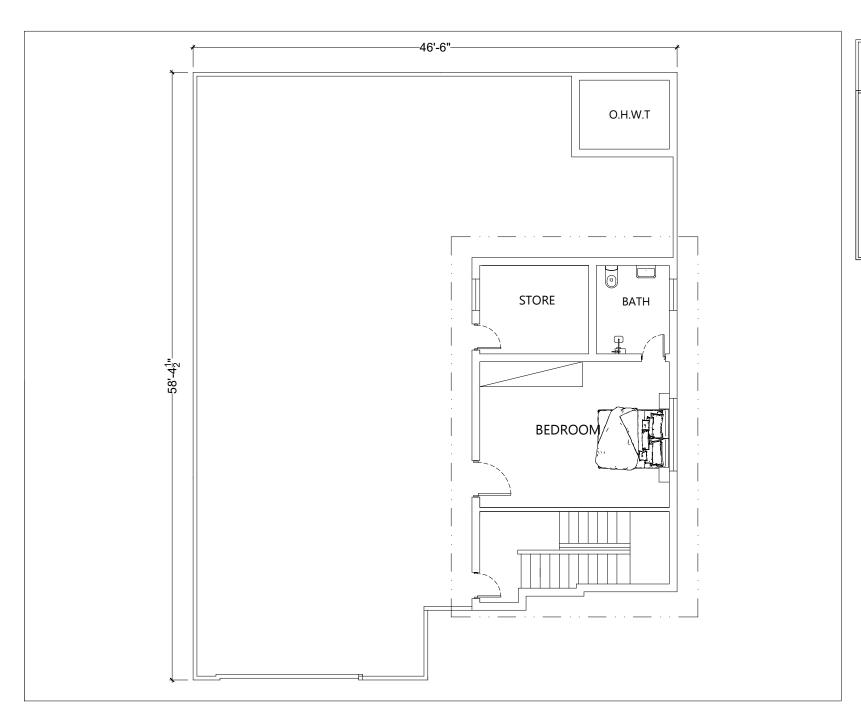



SKART DESIGN STUDIO

LET'S VISUALISE YOUR DREAM ARCHITECTURE, INTERIOR DESIGN WOOD WORKS

Voice: +92 313 5734471 E-mail: Skart.design.studio@gmail.com

Address: Office # 01, Devis Road Habibullah Street, Near Durand Rd, Lahore, Pakistan.

THESE DRAWINGS REMAIN THE PROPERTY OF SKART Design Studio ANY REPRODUCTION WILL CONSIDERED TO BE UNLAWFUL. ELECTRICAL CONSULTANT:

SKART DESIGN STUDIO

STRUCTURAL CONSULTANT:

SKART DESIGN STUDIO

PUBLIC HEALTH CONSULTANT:

SKART DESIGN STUDIO

DESIGN PROPOSAL


NOTES:

Drawn by: Ar.Tasneem Designed by: Ar.Tasneem

ID No: A-201 Scale: AS SHOWN DATE: 10-01-2025 REVISED DATE: 00-00-2025 REVISION NO: 00

MUMTY FLOOR FURNITURE LAYOUT PLAN

Original drawing is A3. Scale entities accordingly if reduced Sheet Number:

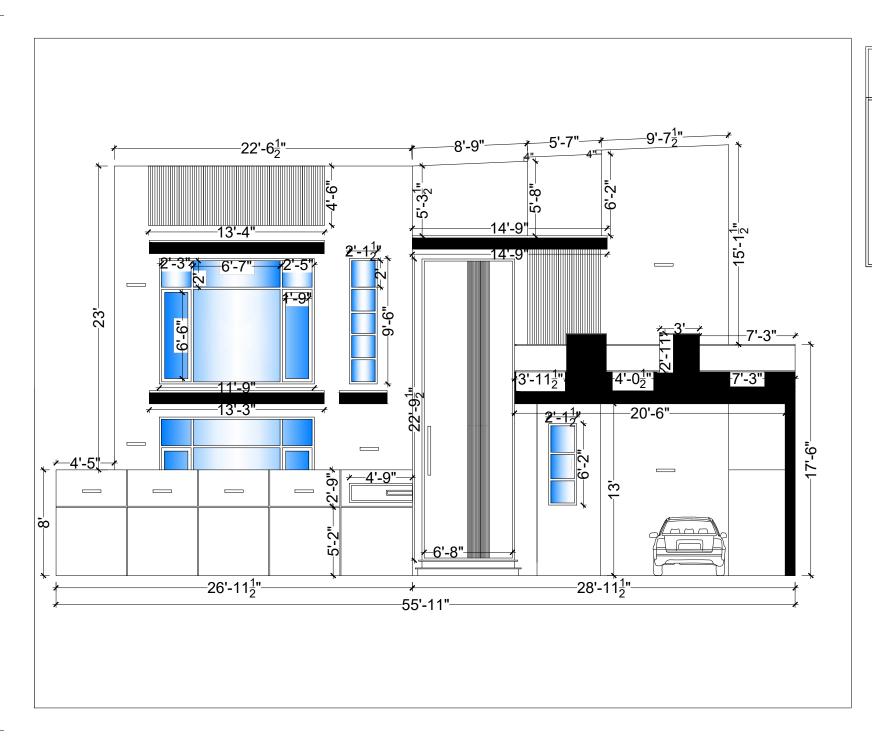





SKART DESIGN STUDIO

LET'S VISUALISE YOUR DREAM ARCHITECTURE , INTERIOR DESIGN WOOD WORKS Voice: +92 313 5734471

E-mail: Skart.design.studio@gmail.com

Address: Office # 01, Devis Road Habibullah Street, Near Durand Rd, Lahore, Pakistan.

THESE DRAWINGS REMAIN THE PROPERTY OF SKART Design Studio ANY REPRODUCTION WILL CONSIDERED TO BE UNLAWFUL. ELECTRICAL CONSULTANT:

SKART DESIGN STUDIO

STRUCTURAL CONSULTANT:

SKART DESIGN STUDIO

PUBLIC HEALTH CONSULTANT:

SKART DESIGN STUDIO

DESIGN PROPOSAL


NOTES:

Designed by: Ar.Tasneem

ID No: A-201 Scale: AS SHOWN DATE: 10-01-2025

FRONT ELEVATION HATCH PLAN.

Original drawing is A3. Scale entitles accordingly if reduced Sheet Number:

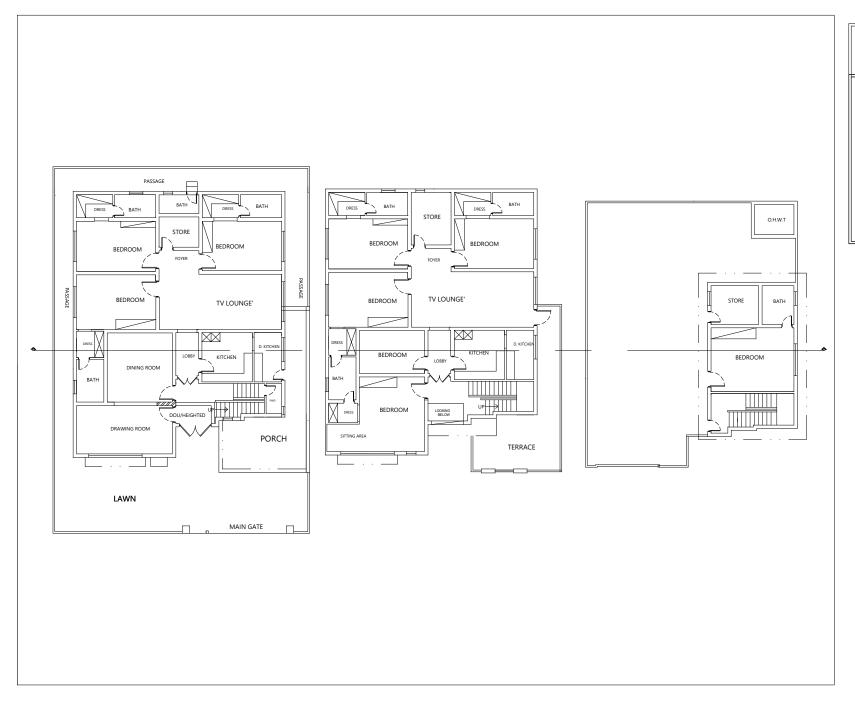



SKART DESIGN STUDIO

LET'S VISUALISE YOUR DREAM ARCHITECTURE , INTERIOR DESIGN WOOD WORKS Voice: +92 313 5734471

E-mail: Skart.design.studio@gmail.com

Address: Office # 01, Devis Road Habibullah Street, Near Durand Rd, Lahore, Pakistan.

THESE DRAWINGS REMAIN THE PROPERTY OF SKART Design Studio ANY REPRODUCTION WILL CONSIDERED TO BE UNLAWFUL. ELECTRICAL CONSULTANT:

SKART DESIGN STUDIO

STRUCTURAL CONSULTANT:

SKART DESIGN STUDIO

PUBLIC HEALTH CONSULTANT:

SKART DESIGN STUDIO

DESIGN PROPOSAL

NOTES:


Drawn by: Ar.Tasneem

Designed by: Ar.Tasneem

ID No: A-201 Scale: AS SHOWN DATE: 10-01-2025 REVISED DATE: 00-00-2025 REVISION NO: 00

SECTION PLAN A'

Original drawing is A3. Scale entities accordingly if reduced Sheet Number:

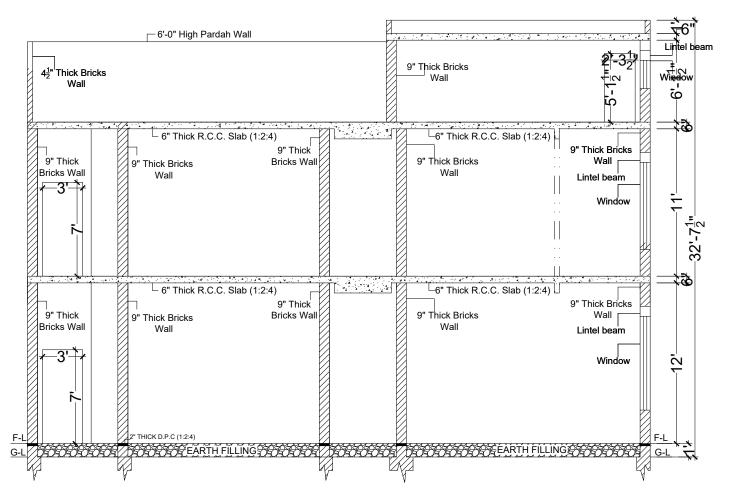

X-Section At A-A



THESE DRAWINGS REMAIN THE PROPERTY OF SKART Desi ELECTRICAL CONSULTANT:

SKART DESIGN STUDIO

STRUCTURAL CONSULTANT:

SKART DESIGN STUDIO

PUBLIC HEALTH CONSULTANT:

SKART DESIGN STUDIO

DESIGN PROPOSAL

NOTES:

Designed by: Ar. Tasneem

ID No: Scale: DATE: A-201 AS SHOWN 10-01-2025

SECTION PLAN A'

Original drawing is A3. Scale entities accordingly if reduced Sheet Number:

DIMENSION LAYOUTS & ELEVATIONS

PROJECT TITLE:

Mr. MUSTAFA Residential

Architecture Plan.



SKART DESIGN STUDIO

LET'S VISUALISE YOUR DREAM ARCHITECTURE, INTERIOR DESIGN

> Voice: +92 313 5734471

E-mail: Skart.design.studio@gmail.com

Address: Office # 01, Devis Road Habibullah Street, Near Durand Rd, Lahore, Pakistan

THESE DRAWINGS REMAIN THE PROPERTY OF SKART Design Studios any reproduction will considered to be unlawful.

ELECTRICAL CONSULTANT:

SKART DESIGN STUDIO

STRUCTURAL CONSULTANT:

SKART DESIGN STUDIO

PUBLIC HEALTH CONSULTANT:

SKART DESIGN STUDIO

DESIGN PROPOSAL

NOTES:

SKART DESIGN STUDIO DOES NOT PROVIDE A

AND FOUNDATION ON SITE.

SKAPT DESIGN STIPM ISSUED A GROWN D

PLAN FOR EXCAVATION AND FOUNDATION ON-S

SKART DESIGN STUDIO ONLY PROVIDES THE

EXCAVATION AND FOUNDATION DETAILED PLA FOR STARTING CONSTRUCTION WORK ON SITE

 SKART DESIGN STUDIO WILL NOT BE RESPONSIBLE IN CASE OF ANY VARIATION OF

MISTAKE ON-SITE AT THE TIME OF CONSTRI

 IN CASE OF ANY KIND OF MISTAKE OR DIFFI IN SIZES IN THE FOUNDATION AND EXCAVAT

DURING CONSTRUCTION, THE SITE WILL NOT

APPROVED BY THE ARCHITECT.


Drawn by: Ar.Tasneem
Designed by: Ar.Tasneem

ID No: A-201 Scale: AS SHOWN DATE: 10-01-2025 REVISED DATE: 00-00-2025 REVISION NO: 00

Shee

TITLE PAGE DIMENSION LAYOUTS PLAN

Original drawing is A3. Scale entities accordingly if reduced

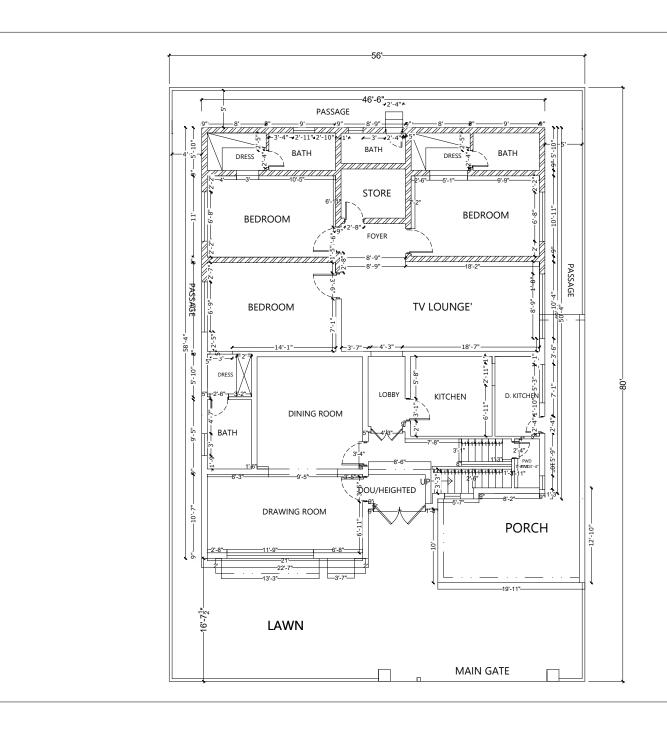



SKART DESIGN STUDIO

LET'S VISUALISE YOUR DREAM ARCHITECTURE , INTERIOR DESIGN WOOD WORKS Voice: +92 313 5734471

E-mail: Skart.design.studio@gmail.com

Address: Office # 01, Devis Road Habibullah Street, Near Durand Rd, Lahore, Pakistan.

THESE DRAWINGS REMAIN THE PROPERTY OF SKART Design Studio ANY REPRODUCTION WILL CONSIDERED TO BE UNLAWFUL. ELECTRICAL CONSULTANT:

SKART DESIGN STUDIO

STRUCTURAL CONSULTANT:

SKART DESIGN STUDIO

PUBLIC HEALTH CONSULTANT:

SKART DESIGN STUDIO

DESIGN PROPOSAL


NOTES:

Designed by: Ar Tasneem

ID No: Scale: DATE: A-201 AS SHOWN 10-01-2025 REVISED DATE: 00-00-2025 REVISION NO: 00

GROUND FLOOR DIMENSION LAYOUT PLAN

Original drawing is A3. Scale entities accordingly if reduced Sheet Number:

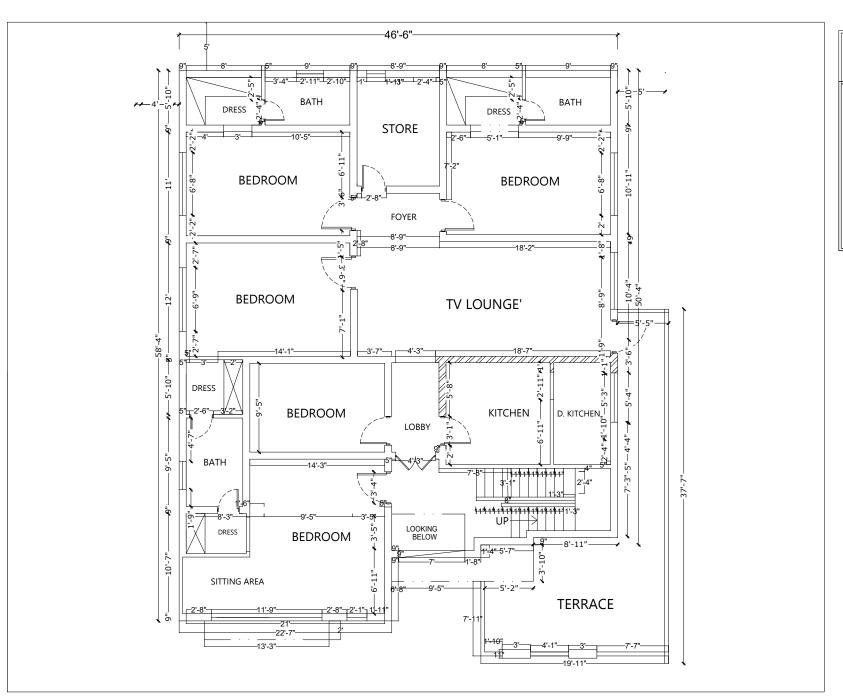





SKART DESIGN STUDIO

LET'S VISUALISE YOUR DREAM ARCHITECTURE , INTERIOR DESIGN WOOD WORKS

Voice: +92 313 5734471

E-mail: Skart.design.studio@gmail.com

Address: Office # 01, Devis Road Habibullah Street, Near Durand Rd, Lahore, Pakistan.

THESE DRAWINGS REMAIN THE PROPERTY OF SKART Design Studio ELECTRICAL CONSULTANT:

SKART DESIGN STUDIO STRUCTURAL CONSULTANT:

SKART DESIGN STUDIO

PUBLIC HEALTH CONSULTANT:

SKART DESIGN STUDIO

DESIGN PROPOSAL


NOTES:

Designed by: Ar Tasneem

ID No: Scale: DATE: A-201 AS SHOWN 10-01-2025 REVISED DATE: 00-00-2025 REVISION NO: 00

FIRST FLOOR DIMENSION LAYOUT

Original drawing is A3. Scale entitles accordingly if reduced Sheet Number:

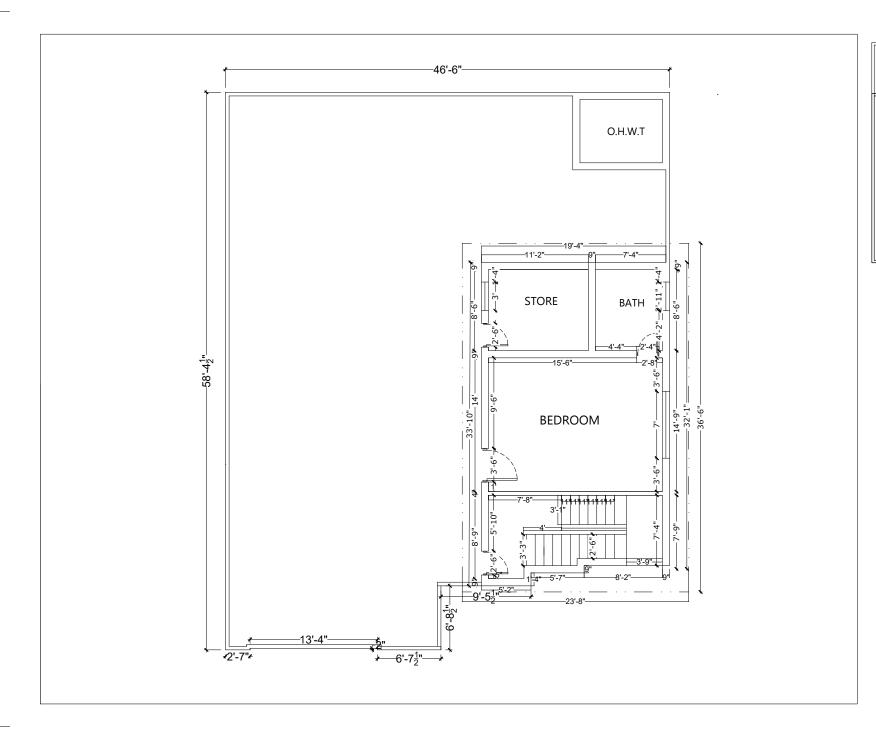



SKART DESIGN STUDIO

LET'S VISUALISE YOUR DREAM ARCHITECTURE , INTERIOR DESIGN WOOD WORKS

Voice: +92 313 5734471

E-mail: Skart.design.studio@gmail.com

Address: Office # 01, Devis Road Habibullah Street, Near Durand Rd, Lahore, Pakistan.

THESE DRAWINGS REMAIN THE PROPERTY OF SKART Design Studio ANY REPRODUCTION WILL CONSIDERED TO BE UNLAWFUL. ELECTRICAL CONSULTANT:

SKART DESIGN STUDIO

STRUCTURAL CONSULTANT:

SKART DESIGN STUDIO

PUBLIC HEALTH CONSULTANT:

SKART DESIGN STUDIO

DESIGN PROPOSAL


NOTES:

Designed by: Ar.Tasneem

ID No: Scale: DATE: A-201 AS SHOWN 10-01-2025 REVISED DATE: 00-00-2025 REVISION NO: 00

MUMTY FLOOR DIMENSION LAYOUT PLAN

Original drawing is A3. Scale entitles accordingly if reduced Sheet Number:

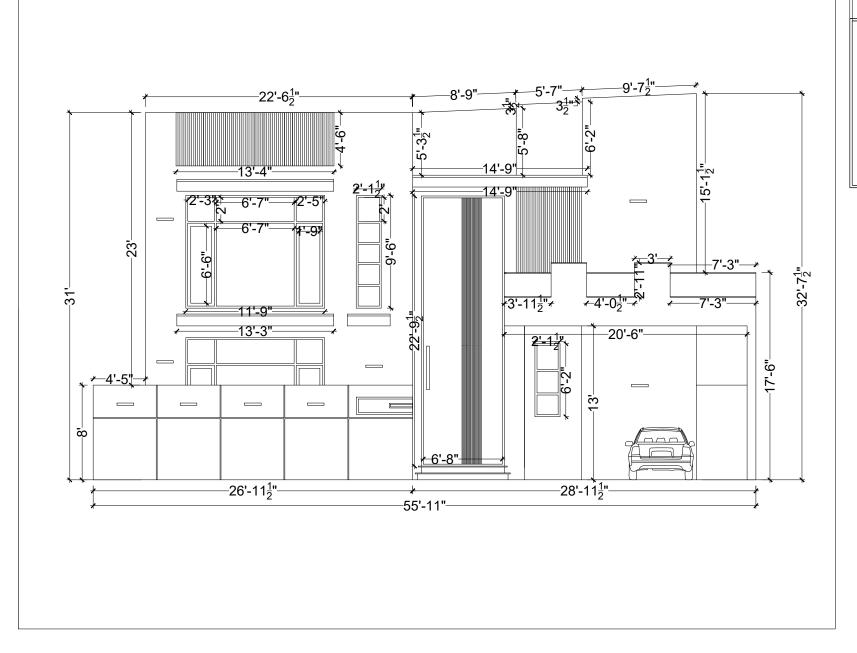



SKART DESIGN STUDIO

LET'S VISUALISE YOUR DREAM ARCHITECTURE , INTERIOR DESIGN WOOD WORKS

Voice: +92 313 5734471

E-mail: Skart.design.studio@gmail.com

Address: Office # 01, Devis Road Habibullah Street, Near Durand Rd, Lahore, Pakistan.

THESE DRAWINGS REMAIN THE PROPERTY OF SKART Design Studio ANY REPRODUCTION WILL CONSIDERED TO BE UNLAWFUL. ELECTRICAL CONSULTANT: SKART DESIGN STUDIO

STRUCTURAL CONSULTANT:

SKART DESIGN STUDIO

PUBLIC HEALTH CONSULTANT:

SKART DESIGN STUDIO

DESIGN PROPOSAL

NOTES:

Designed by: Ar.Tasneem

ID No: A-201 Scale: AS SHOWN DATE: 10-01-2025 REVISED DATE: 00-00-2025 REVISION NO: 00

FRONT ELEVATION DIMENSION PLAN

Original drawing is A3. Scale entities accordingly if reduced Sheet Number:

DOOR & WINDOW SCHEDULE LAYOUT **PLANS**

PROJECT TITLE Mr. MUSTAFA Residential



SKART DESIGN STUDIO

LET'S VISUALISE YOUR DREAM ARCHITECTURE . INTERIOR DESIGN

Voice: +92 313 5734471

Skart.design.studio@gmail.com

Address: Office # 01, Devis Road Habibullah Street. Near Durand Rd. Lahore.

THESE DRAWINGS REMAIN THE PROPERTY OF SKART Design ANY REPRODUCTION WILL CONSIDERED TO BE UNLAWFUL. ELECTRICAL CONSULTANT:

SKART DESIGN STUDIO

STRUCTURAL CONSULTANT:

SKART DESIGN STUDIO

PUBLIC HEALTH CONSULTANT:

SKART DESIGN STUDIO


DESIGN PROPOSAL

Designed by: Ar. Tasneem

10-01-2025

TITLE PAGE DOOR & WINDOW SCHEDULE LAYOUT PLAN

Original drawing is A3. Scale entities accordingly if reduced

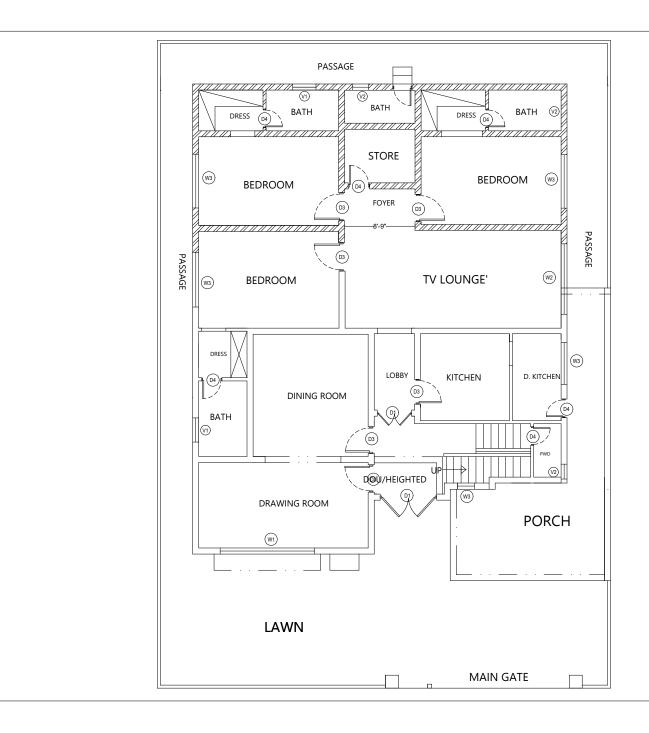





SKART DESIGN STUDIO

LET'S VISUALISE YOUR DREAM ARCHITECTURE , INTERIOR DESIGN WOOD WORKS

Voice: +92 313 5734471 E-mail: Skart.design.studio@gmail.com

Address: Office # 01, Devis Road Habibullah Street, Near Durand Rd, Lahore, Pakistan.

THESE DRAWINGS REMAIN THE PROPERTY OF SKART Design Studio ANY REPRODUCTION WILL CONSIDERED TO BE UNLAWFUL. ELECTRICAL CONSULTANT:

SKART DESIGN STUDIO

STRUCTURAL CONSULTANT:

SKART DESIGN STUDIO

PUBLIC HEALTH CONSULTANT:

SKART DESIGN STUDIO

DESIGN PROPOSAL

NOTES:

Designed by: Ar.Tasneem

ID No: Scale: DATE: A-201 AS SHOWN 10-01-2025 REVISED DATE: 00-00-2025 REVISION NO: 00

GROUND FLOOR DOOR & WINDOW SCHEDULE LAYOUT PLAN

Original drawing is A3. Scale entitles accordingly if reduced Sheet Number:







SKART DESIGN STUDIO

LET'S VISUALISE YOUR DREAM ARCHITECTURE , INTERIOR DESIGN WOOD WORKS Voice: +92 313 5734471

E-mail: Skart.design.studio@gmail.com

Address: Office # 01, Devis Road Habibullah Street, Near Durand Rd, Lahore, Pakistan.

THESE DRAWINGS REMAIN THE PROPERTY OF SKART Design Studio ELECTRICAL CONSULTANT:

SKART DESIGN STUDIO

STRUCTURAL CONSULTANT:

SKART DESIGN STUDIO

PUBLIC HEALTH CONSULTANT:

SKART DESIGN STUDIO


DESIGN PROPOSAL

NOTES:

Designed by: Ar Tasneem

ID No: Scale: DATE: A-201 AS SHOWN 10-01-2025

FIRST FLOOR DOOR & WINDOW SCHEDULE LAYOUT PLAN Original drawing is A3. Scale entitles accordingly if reduced Sheet Number:

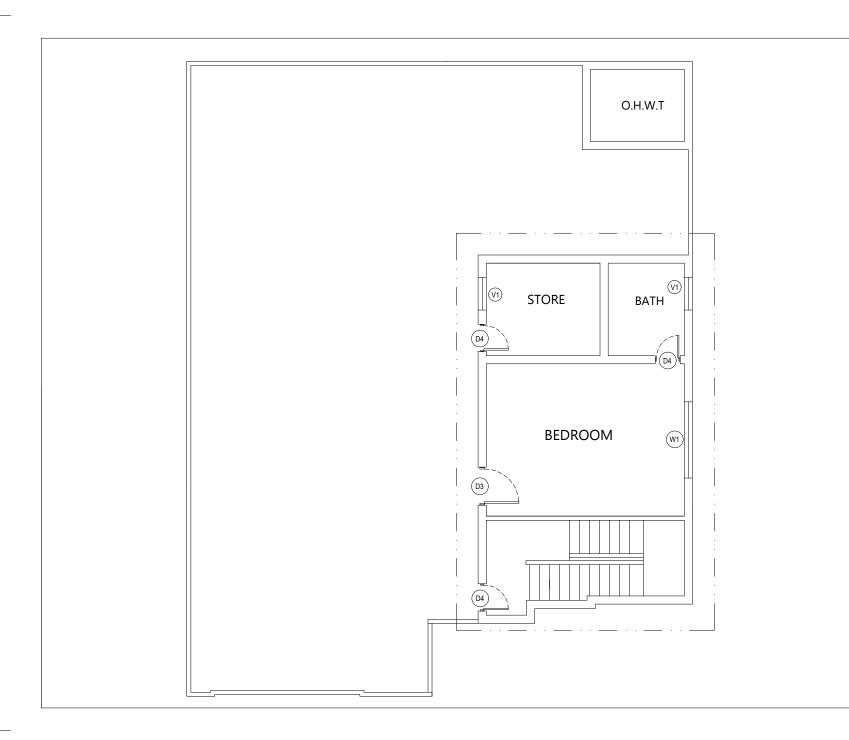



SKART DESIGN STUDIO

LET'S VISUALISE YOUR DREAM ARCHITECTURE, INTERIOR DESIGN WOOD WORKS

Voice: +92 313 5734471

E-mail: Skart.design.studio@gmail.com

Address: Office # 01, Devis Road Habibullah Street, Near Durand Rd, Lahore, Pakistan.

THESE DRAWINGS REMAIN THE PROPERTY OF SKART Design Studio ANY REPRODUCTION WILL CONSIDERED TO BE UNLAWFUL. ELECTRICAL CONSULTANT:

SKART DESIGN STUDIO

STRUCTURAL CONSULTANT:

SKART DESIGN STUDIO PUBLIC HEALTH CONSULTANT:

SKART DESIGN STUDIO

DESIGN PROPOSAL

NOTES:

Drawn by: Ar.Tasneem Designed by: Ar.Tasneem

ID No: A-201 Scale: AS SHOWN DATE: 10-01-2025 REVISED DATE: 00-00-2025 REVISION NO: 00

MUMTY FLOOR DOOR & WINDOW SCHEDULE LAYOUT PLAN

Original drawing is A3. Scale entitles accordingly if reduced Sheet Number:

Schedule of Doors & Windows						
Туре	Dimension	Sill	Quantity	Discription		
D1)	5'-0"x9'-0"	0'-0"	01	Double Leaf Double Swing Glazed Flush Door		
D2	5'-0"x7'-0"	0'-0"	01	Double Leaf Double Swing Glazed Flush Door		
D3	3'-6"X7'-6"	0'-0"	08	Single Leaf Single Swing Wooden Flush Door		
D4	2'-6"x7'-0"	0'-0"	05	Single Leaf Single Swing Wooden Flush Door		
(D5)						
W1)	9'-6"X6'-6"	0'-6"	01	Aluminum Single Glazed Sliding Window		
W2	6'-0"x6'-6"	0'-6"	03	Aluminum Single Glazed Sliding Window		
W3	5'-0"x6'-6"	0'-6"	03	Aluminum Single Glazed Sliding Window		
W4	4'-0"X6'-6"	0'-6"	02	Aluminum Single Glazed Sliding Window		
W5)	4'-0"X3'-6"	3'-6"	02	Aluminum Single Glazed Sliding Window		
W6	2'-3"X4'-0"	3'-6"	02	Aluminum Single Glazed Sliding Window		
V1	2'-0"X2'-0"	5'-0"	04	Aluminum Single Glazed Sliding Window		
V2	1'-0"X2'-0"	5'-0"	01	Aluminum Single Glazed Sliding Window		





SKART DESIGN STUDIO

LET'S VISUALISE YOUR DREAM ARCHITECTURE, INTERIOR DESIGN WOOD WORKS

Voice: +92 313 5734471

E-mail: Skart.design.studio@gmail.com

Address: Office # 01, Devis Road Habibullah Street, Near Durand Rd, Lahore, Pakistan.

THESE DRAWINGS REMAIN THE PROPERTY OF SKART Design Studio ANY REPRODUCTION WILL CONSIDERED TO BE UNLAWFUL.

ELECTRICAL CONSULTANT:

SKART DESIGN STUDIO

STRUCTURAL CONSULTANT:

SKART DESIGN STUDIO

PUBLIC HEALTH CONSULTANT:

SKART DESIGN STUDIO

DESIGN PROPOSAL

NOTES:

SKART DESIGN STUDIO DOES NOT PROVIDE A

GROUND FLOOR LAYOUT PLAN FOR EXCAVATION AND FOUNDATION ON SITE.

PLAN FOR EXCAVATION AND FOUNDATION ON-SITE

EXCAVATION AND FOUNDATION DETAILED PLA

FOR STARTING CONSTRUCTION WORK ON SITE.
 SKART DESIGN STUDIO WILL NOT BE

 SKART DESIGN STUDIO WILL NOT BE RESPONSIBLE IN CASE OF ANY VARIATION OR

IN CASE OF ANY KIND OF MISTAKE OR DIFFE

IN SIZES IN THE FOUNDATION AND EXCAVATION OF STREET OF STREET WILL NOT BE

DURING CONSTRUCTION, THE SITE WILL NOT BE APPROVED BY THE ARCHITECT.

Drawn by: Ar.Tasneem
Designed by: Ar.Tasneem

ID No: A-201
Scale: AS SHOWN
DATE: 10-01-2025
REVISED DATE: 00-00-2025
REVISION NO: 00

Sheet Titl

LEGEND DOOR & WINDOW SCHEDULE

Original drawing is A3. Scale entities accordingly if reduced Sheet Number:

ELECTRICAL LAYOUT PLANS

PROJECT TITLE:

Mr. MUSTAFA Residential

Architecture Plan.



SKART DESIGN STUDIO

LET'S VISUALISE YOUR DREAM ARCHITECTURE, INTERIOR DESIGN

> Voice: +92 313 5734471

E-mail: Skart.design.studio@gmail.com

Address: Office # 01, Devis Road Habibullah Street, Near Durand Rd, Lahore, Pakistan

THESE DRAWINGS REMAIN THE PROPERTY OF SKART Design Studio
ANY REPRODUCTION WILL CONSIDERED TO BE UNLAWFUL.

ELECTRICAL CONSULTANT:

SKART DESIGN STUDIO

STRUCTURAL CONSULTANT:

SKART DESIGN STUDIO

PUBLIC HEALTH CONSULTANT:

SKART DESIGN STUDIO

DESIGN PROPOSAL

NOTES

SKART DESIGN STUDIO DOES NOT PROVIDE A

AND FOUNDATION ON SITE.

PLAN FOR EXCAVATION AND FOUNDATION ON-SI

 SKART DESIGN STUDIO ONLY PROVIDES TH EXCAVATION AND FOUNDATION DETAILED PI

FOR STARTING CONSTRUCTION WORK ON SIT

SKART DESIGN STUDIO WILL NOT BE

MISTAKE ON-SITE AT THE TIME OF CONSTR

 IN CASE OF ANY KIND OF MISTAKE OR DIFFI IN SIZES IN THE FOUNDATION AND EXCAVAT

DURING CONSTRUCTION, THE SITE WILL NOT

APPROVED BY THE ARCHITECT.


Drawn by: Ar.Tasneem
Designed by: Ar.Tasneem

ID No: A-201
Scale: AS SHOWN
DATE: 10-01-2025
REVISED DATE: 00-00-20
REVISION NO: 00

Shee

TITLE PAGE ELECTRIC LAYOUT PLAN

Original drawing is A3. Scale entities accordingly if reduced

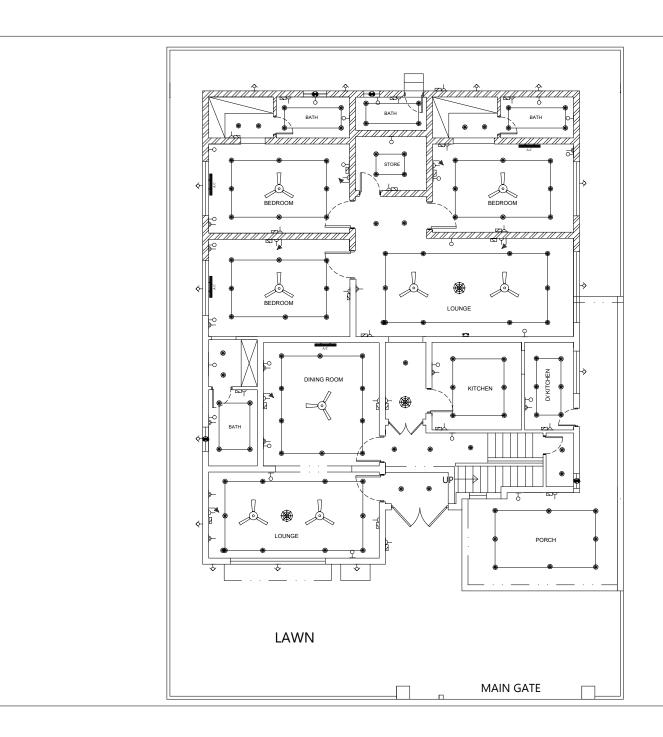



SKART DESIGN STUDIO

LET'S VISUALISE YOUR DREAM ARCHITECTURE , INTERIOR DESIGN WOOD WORKS

Voice: +92 313 5734471

E-mail: Skart.design.studio@gmail.com

Address: Office # 01, Devis Road Habibullah Street, Near Durand Rd, Lahore, Pakistan.

THESE DRAWINGS REMAIN THE PROPERTY OF SKART Design Studio ANY REPRODUCTION WILL CONSIDERED TO BE UNLAWFUL. ELECTRICAL CONSULTANT:

SKART DESIGN STUDIO

STRUCTURAL CONSULTANT:

SKART DESIGN STUDIO

PUBLIC HEALTH CONSULTANT:

SKART DESIGN STUDIO

DESIGN PROPOSAL


NOTES:

Drawn by: Ar.Tasneem Designed by: Ar.Tasneem

ID No: A-201 Scale: AS SHOWN DATE: 10-01-2025 REVISED DATE: 00-00-2025 REVISION NO: 00

GROUND FLOOR ELECTRIC LAYOUT **PLAN**

Original drawing is A3. Scale entities accordingly if reduced Sheet Number:

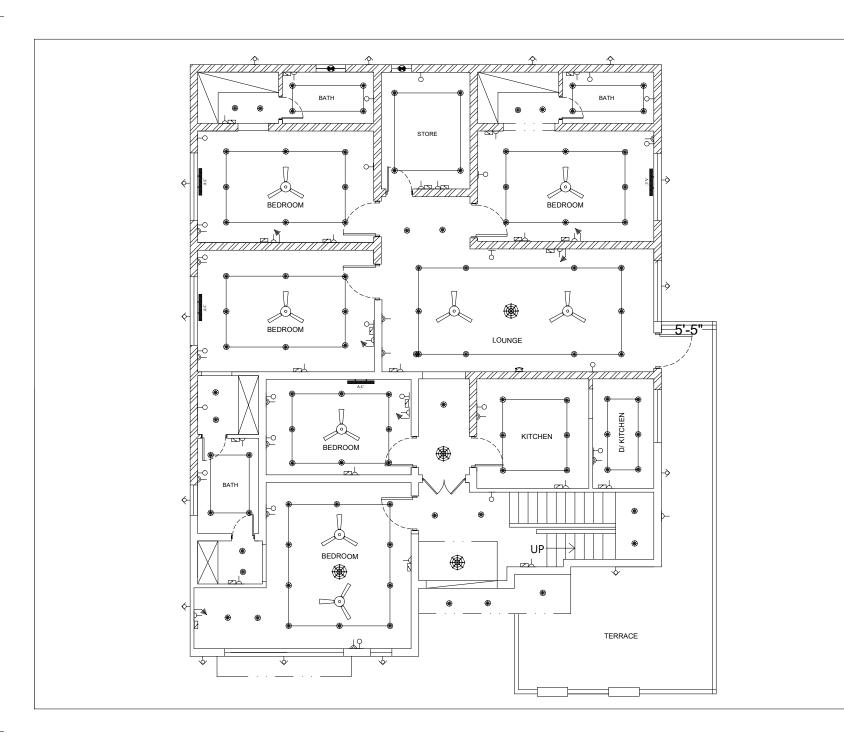





SKART DESIGN STUDIO

LET'S VISUALISE YOUR DREAM ARCHITECTURE , INTERIOR DESIGN WOOD WORKS

Voice: +92 313 5734471

E-mail: Skart.design.studio@gmail.com

Address: Office # 01, Devis Road Habibullah Street, Near Durand Rd, Lahore, Pakistan.

THESE DRAWINGS REMAIN THE PROPERTY OF SKART Design Studio ANY REPRODUCTION WILL CONSIDERED TO BE UNLAWFUL. ELECTRICAL CONSULTANT:

SKART DESIGN STUDIO

STRUCTURAL CONSULTANT:

SKART DESIGN STUDIO

PUBLIC HEALTH CONSULTANT:

SKART DESIGN STUDIO

DESIGN PROPOSAL


NOTES:

Drawn by: Ar-Tasneem Designed by: Ar.Tasneem

ID No: A-201 Scale: AS SHOWN DATE: 10-01-2025 REVISED DATE: 00-00-2025 REVISION NO: 00

FIRST FLOOR ELECTRIC LAYOUT PLAN

Original drawing is A3. Scale entities accordingly if reduced Sheet Number:

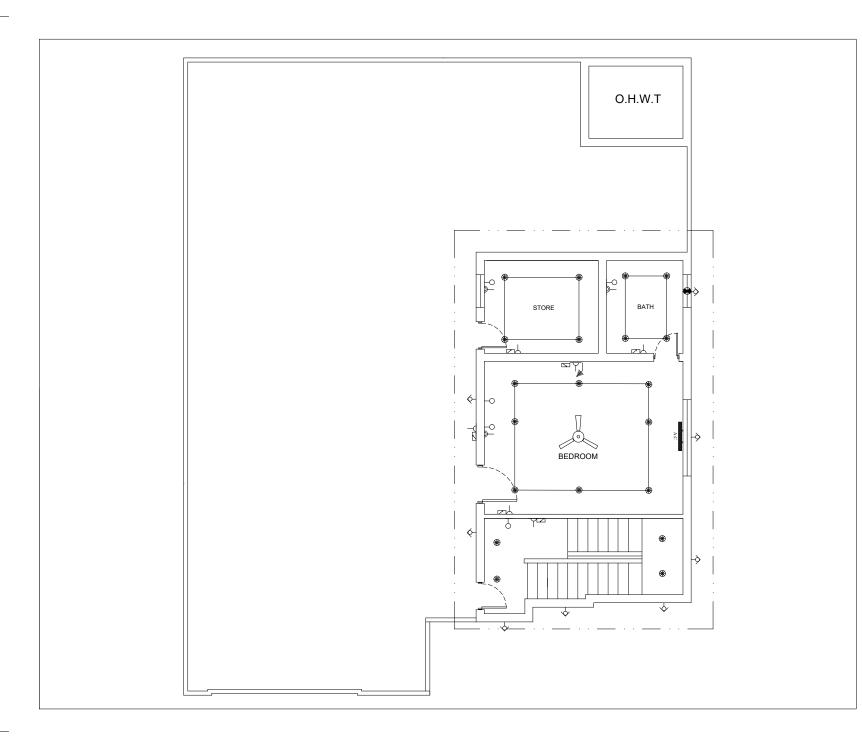

PROJECT TITLE: Mr. MUSTAFA Residential

Architecture Plan.



SKART DESIGN STUDIO

LET'S VISUALISE YOUR DREAM ARCHITECTURE , INTERIOR DESIGN WOOD WORKS

Voice: +92 313 5734471 E-mail: Skart.design.studio@gmail.com

Address: Office # 01, Devis Road Habibullah Street, Near Durand Rd, Lahore, Pakistan.

THESE DRAWINGS REMAIN THE PROPERTY OF SKART Design Studio ANY REPRODUCTION WILL CONSIDERED TO BE UNLAWFUL. ELECTRICAL CONSULTANT:

SKART DESIGN STUDIO

STRUCTURAL CONSULTANT:

SKART DESIGN STUDIO

PUBLIC HEALTH CONSULTANT:

SKART DESIGN STUDIO

DESIGN PROPOSAL

NOTES:

Drawn by: Ar.Tasneem Designed by: Ar.Tasneem

ID No: A-201 Scale: AS SHOWN DATE: 10-01-2025 REVISED DATE: 00-00-2025 REVISION NO: 00

MUMTY FLOOR ELECTRIC LAYOUT PLAN

Original drawing is A3. Scale entities accordingly if reduced Sheet Number:

LEGEND FOR ELECTRICAL SYMBOLS					
	3P-15 AMP POWER PLUG	₩	CEILING LIGHT HANGING POINT		
	3P-5 AMP LIGHT PLUG		CHANDELIER		
	SWITCH PLATE	•	EXHAUST FAN		
	DISTRIBUTION BOARD	****	TV. WALL POINT.		
<u> </u>	PHONE/ INTERCOM		TUBE LIGHT / ROD		
├ >	EXTERNAL WALL BRACKET LIGHT (W.P)		A.C		
Ю	WALL BRACKET LIGHT	•	BELL PUSH		
	FANCY BELL		CEILING FAN		
	GATE LIGHT		GARDEN LIGHT		
	C.C.T.V CAMARA				

IFCEND FOR FIFCTRICAL SYMBOLS

GENERAL NOTE.

- * ALL WIRING SHALL BE CONCEALED IN GOOD QUALITY P.V.C. CONDUITS IN WALLS, COLUMNS & CEILING ETC.
- THE MINIMUM SIZE OF P.V.C. CONDUIT SHALL NOT BE LESS THEN 3/4" DIA.
- LIGHT CIRCUIT WIRING SHALL BE 7/.029 AND LIGHT POINT WIRING SHALL BE WITH 3/.036 P.V.C. SINGLE CORE.
- ALL POWER PLUGS WIRING SHALL HAVE INDEPENDENT CIRCUIT FROM POWER DISTRIBUTION BOARD.
- ALL POWER PLUGS WIRING SHALL BE WITH 7/.044 P.V.C. SINGLE CORE WIRE.
- * SUPERIOR QUALITY CIRCUIT BREAKERS, EARTH PROTECTION, MAIN SWITCH, INDICATORS, CHANGE OVER ETC. WILL BE USED IN THE DISTRIBUTION BOARD
- 14 S.W.G. [2.03mm] BARE SOLID COPPER EARTH WIRE SHALL RUN ALONG POWER PLUG WIRING 15 AMP, & LIGHT PLUG WIRING 5 AMP.
- ALL CONDUIT, MAIN/SUB DISTRIBUTION BOARD, IRON CLAD MAIN SWITCH, BACK BOXES AND ENERGY METER WILL HAVE FULL ELECTRIC CONTINUITY & WILL BE BOUND TO EARTH.
- * ALL PHASE / LIVE WIRES WILL BE RED IN COLOR ALL NEUTRAL WIRES WILL BE BLACK IN COLOR ALL EARTH WIRES WILL BE GREEN IN COLOR
- * THE MOUNTING HEIGHT ABOVE FINISHED FLOOR LEVEL FOR VARIOUS ELECTRIC POINTS, SHALL BE AS FOLLOWS, OR AS OTHER WISE INDICATED ON DRAWING.

HANGING LIGHT CEILING FAN = 9'-6" WALL LIGHT BRACKET. = 7'T08' CHANDELIER = 9'-0" BRACKET FAN / EXHAUST FAN = 9'-6" POWER PLUG 15 AMP. = 0'-8" (In Kitchen 8" Above Counter) LIGHT PLUG 5 AMP (In Kitchen 8" Above Counter) = 0"-8" TUBE LIGHT [BATH] = 7'T08' TUBE LIGHT [KITCHEN] (Under Hood) = 5'-0" SWITCH PLATE MAIN / SUB DISTRIBUTION BOARD. = 4'-0" BUZZER / BELL POINT = 8'-0'

ALL DIMENSIONS FOR MOUNTING OF ELECTRIC POINT ARE TO BE TAKEN FROM FINISHED FLOOR LEVEL TO THE CENTER OF THE POINT.

PROJECT TITLE:
Mr. MUSTAFA
Residential
Architecture Plan.



SKART DESIGN STUDIO

LET'S VISUALISE YOUR DREAM ARCHITECTURE, INTERIOR DESIGN WOOD WORKS Voice: +92313 5734471

E-mail: Skart.design.studio@gmail.com

Address: Office # 01, Devis Road Habibullah Street, Near Durand Rd, Lahore, Pakistan.

THESE DRAWINGS REMAIN THE PROPERTY OF SKART Design Studio ANY REPRODUCTION WILL CONSIDERED TO BE UNLAWFUL.

ELECTRICAL CONSULTANT:

SKART DESIGN STUDIO

STRUCTURAL CONSULTANT:

SKART DESIGN STUDIO

PUBLIC HEALTH CONSULTANT:

SKART DESIGN STUDIO

DESIGN PROPOSAL

NOTES:

SKART DESIGN STUDIO DOES NOT PROVIDE A

SKART DESIGN STUDIO ISSUED A GROUND FLO

PLAN FOR EXCAVATION AND FOUNDATION ON-

 SKART DESIGN STUDIO ONLY PROVIDES THE EXCAVATION AND FOUNDATION DETAILED PL

EXCAVATION AND FOUNDATION DETAILED PL FOR STARTING CONSTRUCTION WORK ON SITE

SKART DESIGN STUDIO WILL NOT BE

RESPONSIBLE IN CASE OF ANY VARIATION OF

MISTAKE ON-SITE AT THE TIME OF CONSTR
 IN CASE OF ANY KIND OF MISTAKE OR DIFF

IN CASE OF ANY KIND OF MISTAKE OR DIFF
 IN SIZES IN THE FOUNDATION AND EXCAVA

DURING CONSTRUCTION, THE SITE WILL NOT

Drawn by: Ar.Tasneem

ID No: A-201
Socie: AS SHOWN

DATE: 10-01-2025

REVISED DATE: 00-00-2025

REVISION NO: 00

Sheet Titles

ELECTRIC LEGEND

Original drawing is A3. Scale entities accordingly if reduced Sheet Number:

PUBLIC HEALTH LAYOUT PLANS

PROJECT TITLE:
Mr. MUSTAFA
Residential

Architecture Plan.



SKART DESIGN STUDIO

LET'S VISUALISE YOUR DREAM ARCHITECTURE, INTERIOR DESIGN

> Voice: +92 313 5734471

E-mail: Skart.design.studio@gmail.com

Address: Office # 01, Devis Road Habibullah Street, Near Durand Rd, Lahore, Pakistan.

THESE DRAWINGS REMAIN THE PROPERTY OF SKART Design Studios and Reproduction will considered to be unlawful.

ELECTRICAL CONSULTANT:

SKART DESIGN STUDIO

STRUCTURAL CONSULTANT:

SKART DESIGN STUDIO

PUBLIC HEALTH CONSULTANT:

SKART DESIGN STUDIO

DESIGN PROPOSAL

NOTES:

SKART DESIGN STUDIO DOES NOT PROVIDE A

AND FOUNDATION ON SITE.

SKART DESIGN STIDIO ISSUED A GROUND FI

PLAN FOR EXCAVATION AND FOUNDATION ON-S AS PER CONTRACTOR AND BUILDER DEMAND.

SKART DESIGN STUDIO ONLY PROVIDES TH

FOR STARTING CONSTRUCTION WORK ON SITE

 SKART DESIGN STUDIO WILL NOT BE RESPONSIBLE IN CASE OF ANY VARIATION OF

MISTAKE ON-SITE AT THE TIME OF CONST

 IN CASE OF ANY KIND OF MISTAKE OR DIFFI IN SIZES IN THE FOUNDATION AND EXCAVAT

DURING CONSTRUCTION, THE SITE WILL NOT

APPROVED BY THE ARCHITECT.


Drawn by: Ar.Tasneem
Designed by: Ar.Tasneem

ID No: A-201
Scale: AS SHOWN
DATE: 10-01-2025
REVISED DATE: 00-00-20
REVISION NO: 00

Sheet T

TITLE PAGE PUBLIC HEALTH LAYOUT PLAN

Original drawing is A3. Scale entities accordingly if reduced

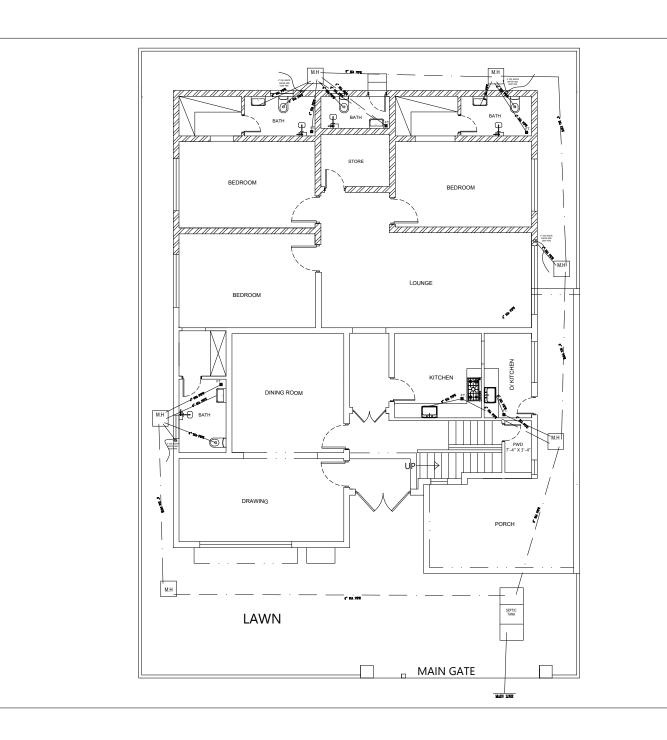

PROJECT TITLE: Mr. MUSTAFA Residential



SKART DESIGN STUDIO

LET'S VISUALISE YOUR DREAM ARCHITECTURE , INTERIOR DESIGN WOOD WORKS

Voice: +92 313 5734471

E-mail: Skart.design.studio@gmail.com

Address: Office # 01, Devis Road Habibullah Street, Near Durand Rd, Lahore, Pakistan.

THESE DRAWINGS REMAIN THE PROPERTY OF SKART Design Studio ANY REPRODUCTION WILL CONSIDERED TO BE UNLAWFUL. ELECTRICAL CONSULTANT:

SKART DESIGN STUDIO

STRUCTURAL CONSULTANT:

SKART DESIGN STUDIO

PUBLIC HEALTH CONSULTANT:

SKART DESIGN STUDIO

DESIGN PROPOSAL


NOTES:

Drawn by: Ar.Tasneem Designed by: Ar.Tasneem

ID No: A-201 Scale: AS SHOWN DATE: 10-01-2025 REVISED DATE: 00-00-2025 REVISION NO: 00

GROUND FLOOR PUBLIC HEALTH LAYOUT PLAN

Original drawing is A3. Scale entitles accordingly if reduced Sheet Number:

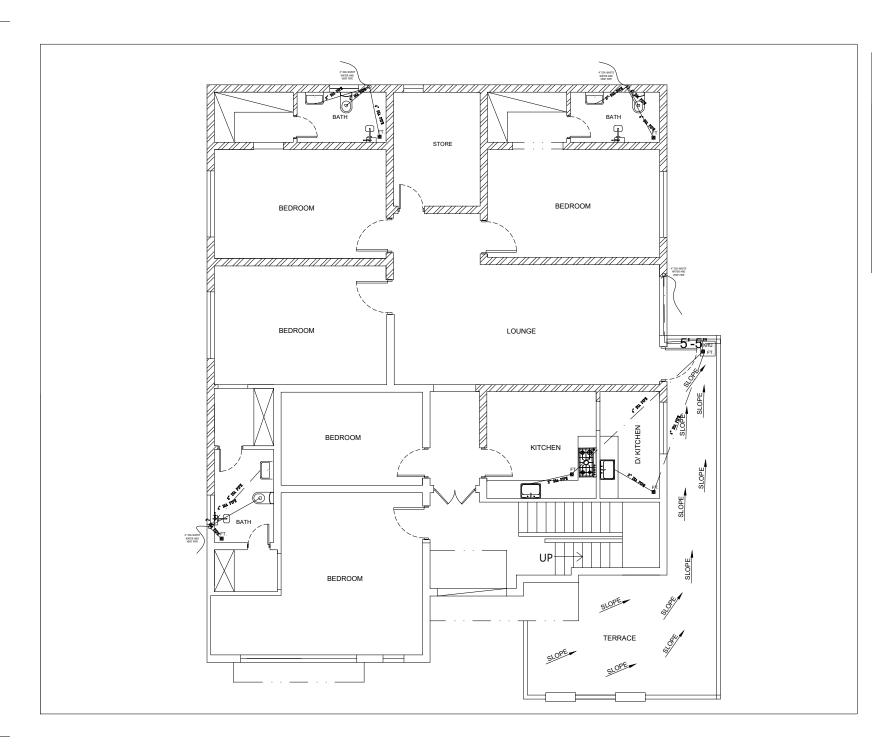



SKART DESIGN STUDIO

LET'S VISUALISE YOUR DREAM ARCHITECTURE , INTERIOR DESIGN WOOD WORKS

Voice: +92 313 5734471

E-mail: Skart.design.studio@gmail.com

Address: Office # 01, Devis Road Habibullah Street, Near Durand Rd, Lahore, Pakistan.

THESE DRAWINGS REMAIN THE PROPERTY OF SKART Design Studio ELECTRICAL CONSULTANT:

SKART DESIGN STUDIO

STRUCTURAL CONSULTANT:

SKART DESIGN STUDIO

PUBLIC HEALTH CONSULTANT:

SKART DESIGN STUDIO

DESIGN PROPOSAL


NOTES:

Designed by: Ar.Tasneem

ID No: A-201 Scale: AS SHOWN DATE: 10-01-2025 REVISED DATE: 00-00-2025 REVISION NO: 00

FIRST FLOOR PUBLIC HEALTH LAYOUT PLAN

Original drowing is A3. Scale entities accordingly if reduced Sheet Number:

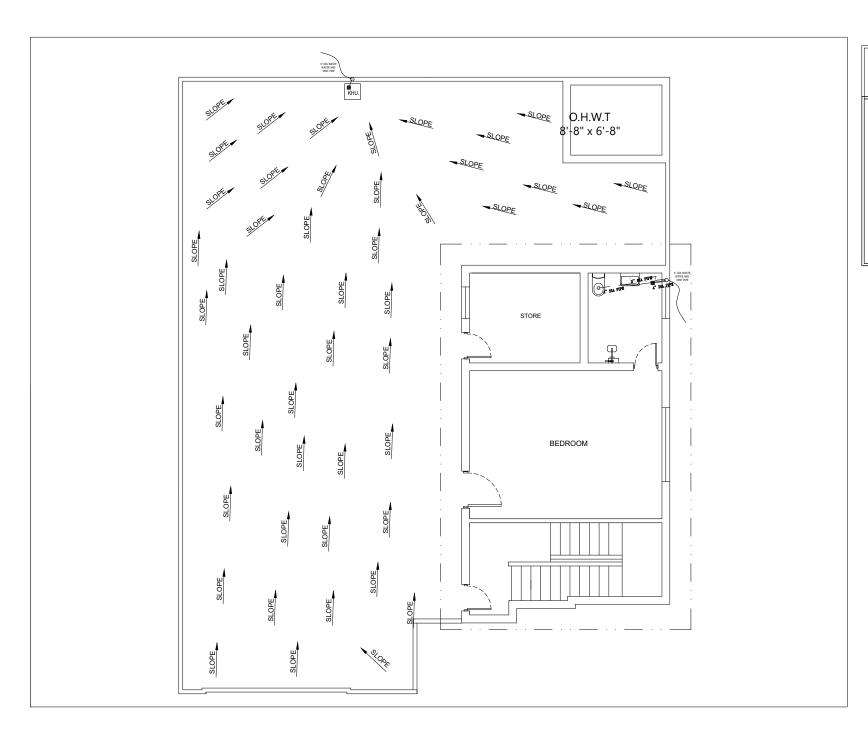



SKART DESIGN STUDIO

LET'S VISUALISE YOUR DREAM ARCHITECTURE , INTERIOR DESIGN WOOD WORKS

Voice: +92 313 5734471

E-mail: Skart.design.studio@gmail.com

Address: Office # 01, Devis Road Habibullah Street, Near Durand Rd, Lahore, Pakistan.

THESE DRAWINGS REMAIN THE PROPERTY OF SKART Design Studio ANY REPRODUCTION WILL CONSIDERED TO BE UNLAWFUL. ELECTRICAL CONSULTANT:

SKART DESIGN STUDIO

STRUCTURAL CONSULTANT:

SKART DESIGN STUDIO

PUBLIC HEALTH CONSULTANT:

SKART DESIGN STUDIO

DESIGN PROPOSAL


NOTES:

Drawn by: Ar.Tasneem Designed by: Ar.Tasneem

ID No: A-201 Scale: AS SHOWN DATE: 10-01-2025 REVISED DATE: 00-00-2025 REVISION NO: 00

MUMTY FLOOR PUBLIC HEALTH LAYOUT PLAN

Original drawing is A3. Scale entities accordingly if reduced Sheet Number:

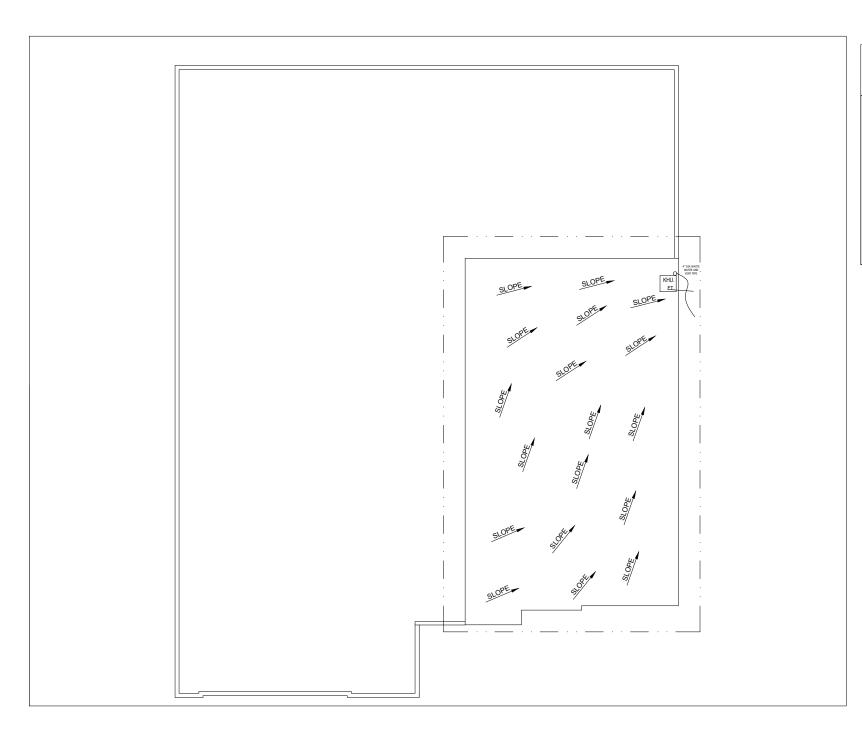



SKART DESIGN STUDIO

LET'S VISUALISE YOUR DREAM ARCHITECTURE , INTERIOR DESIGN WOOD WORKS Voice: +92 313 5734471

E-mail: Skart.design.studio@gmail.com

Address: Office # 01, Devis Road Habibullah Street, Near Durand Rd, Lahore, Pakistan.

THESE DRAWINGS REMAIN THE PROPERTY OF SKART Design Studio ANY REPRODUCTION WILL CONSIDERED TO BE UNLAWFUL. ELECTRICAL CONSULTANT:

SKART DESIGN STUDIO

STRUCTURAL CONSULTANT:

SKART DESIGN STUDIO

PUBLIC HEALTH CONSULTANT:

SKART DESIGN STUDIO

DESIGN PROPOSAL

NOTES:

Drawn by: Ar.Tasneem Designed by: Ar.Tasneem

ID No: A-201 Scale: AS SHOWN DATE: 10-01-2025 REVISED DATE: 00-00-2025 REVISION NO: 00

ROOF TOP PUBLIC HEALTH LAYOUT PLAN

Original drawing is A3. Scale entities accordingly if reduced Sheet Number:

SANITATION LEGEND

1	MAN HOLE 2'X2'
2	GALLI TRAP
3	FLOOR TRAP
4	4" DIA SEWER & VENT PIPE
5	3" DIA WASTE WATER PIPE
6	4" DIA RAIN WATER PIPE
7	6" DIA MAIN SEWER PIPE
8	SEPTIC TANK

Mr. MUSTAFA
Residential
Architecture Plan.



SKART DESIGN STUDIO

LET'S VISUALISE YOUR DREAM ARCHITECTURE, INTERIOR DESIGN WOOD WORKS Voice: +92313 5734471

E-mail: Skart.design.studio@gmail.com

Address: Office # 01, Devis Road Habibullah Street, Near Durand Rd, Lahore, Pakistan.

THESE DRAWINGS REMAIN THE PROPERTY OF SKART Design Studio ANY REPRODUCTION WILL CONSIDERED TO BE UNLAWFUL.

ELECTRICAL CONSULTANT:

SKART DESIGN STUDIO

STRUCTURAL CONSULTANT:

SKART DESIGN STUDIO

PUBLIC HEALTH CONSULTANT:

SKART DESIGN STUDIO

DESIGN PROPOSAL

NOTES

SKART DESIGN STUDIO DOES NOT PROVIDE A

AND FOUNDATION ON SITE.

SKAPT DESIGN STIPLE ISSUED A COMMOD EL

PLAN FOR EXCAVATION AND FOUNDATION ON-SIT

SKART DESIGN STUDIO ONLY PROVIDES THE

FOR STARTING CONSTRUCTION WORK ON SIT
 SKART DESIGN STUDIO WILL NOT BE

 SKART DESIGN STUDIO WILL NOT BE RESPONSIBLE IN CASE OF ANY VARIATION (

IN CASE OF ANY KIND OF MISTAKE OR DIFFE

IN SIZES IN THE FOUNDATION AND EXCAVATION PROPERTY OF THE SIZE WILL MOST BE

DURING CONSTRUCTION, THE SITE WILL NOT I APPROVED BY THE ARCHITECT.


Drawn by: Ar.Tasneem
Designed by: Ar.Tasneem

ID No: A-201
Scole: AS SHOWN
DATE: 10-01-2025
REVISED DATE: 00-00-202
REVISION NO: 00

Sheet Titles

SANITATION LEGEND

Original drawing is A3. Scale entitles accordingly if reduced Sheet Number:

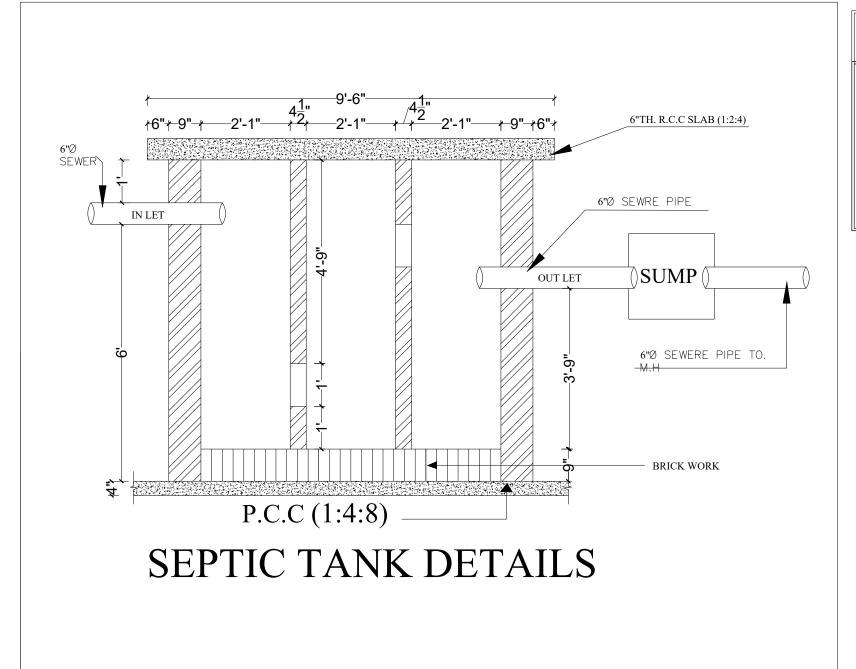





LET'S VISUALISE YOUR DREAM ARCHITECTURE, INTERIOR DESIGN WOOD WORKS

Voice: +92 313 5734471 E-mail: Skart.design.studio@gmail.com

Address: Office # 01, Devis Road Habibullah Street, Near Durand Rd, Lahore, Pakistan.

THESE DRAWINGS REMAIN THE PROPERTY OF SKART Design SI ANY REPRODUCTION WILL CONSIDERED TO BE UNLAWFUL. ELECTRICAL CONSULTANT:

SKART DESIGN STUDIO

STRUCTURAL CONSULTANT:

SKART DESIGN STUDIO

PUBLIC HEALTH CONSULTANT:

SKART DESIGN STUDIO

DESIGN PROPOSAL

NOTES

SKART DESIGN STUDIO DOES NOT PROVIDE A

SKART DESIGN STUDIO ISSUED & GROUND FLO

PLAN FOR EXCAVATION AND FOUNDATION ON-SIT AS PER CONTRACTOR AND BUILDER DEMAND.

EXCAVATION AND FOUNDATION DETAILED PL

FOR STARTING CONSTRUCTION WORK ON SIT
 SKART DESIGN STUDIO WILL NOT BE

 SKART DESIGN STUDIO WILL NOT BE RESPONSIBLE IN CASE OF ANY VARIATION OF

MISTAKE ON-SITE AT THE TIME OF CONSTRI

 IN CASE OF ANY KIND OF MISTAKE OR DIFF.

IN SIZES IN THE FOUNDATION AND EXCAVAT

DURING CONSTRUCTION, THE SITE WILL NOT BE APPROVED BY THE ARCHITECT.

Designed by: Ar.Tasneen

ID No: A-201
Scole: AS SHOWN
DATE: 10-01-2025
REVISED DATE: 00-00-202
REVISION NO: 00

Sheet Title

SEPTIC TANK DETAIL

Original drawing is A3. Scale entities accordingly if reduced Sheet Number:

PLUMBRING LAYOUT PLANS

PROJECT TITLE: Mr. MUSTAFA

Residential Architecture Plan.



SKART DESIGN STUDIO

LET'S VISUALISE YOUR DREAM ARCHITECTURE . INTERIOR DESIGN

Voice: +92 313 5734471

Skart.design.studio@gmail.com

Address: Office # 01, Devis Road Habibullah Street. lear Durand Rd. Lahore.

THESE DRAWINGS REMAIN THE PROPERTY OF SKART Design Studio ANY REPRODUCTION WILL CONSIDERED TO BE UNLAWFUL. ELECTRICAL CONSULTANT:

SKART DESIGN STUDIO

STRUCTURAL CONSULTANT:

SKART DESIGN STUDIO

PUBLIC HEALTH CONSULTANT:

SKART DESIGN STUDIO

DESIGN PROPOSAL

NOTES:


Drawn by: Ar.Tasneem

Designed by: Ar. Tasneem

ID No: A-201 Scale: AS SHOWN DATE: 10-01-2025

TITLE PAGE PLUMBING LAYOUT PLAN

Original drawing is A3. Scale entities accordingly if reduced

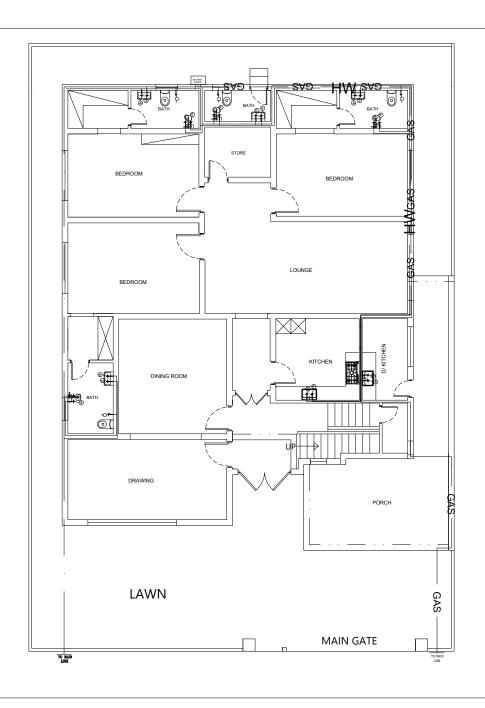





LET'S VISUALISE YOUR DREAM ARCHITECTURE , INTERIOR DESIGN WOOD WORKS

Voice: +92 313 5734471

E-mail: Skart.design.studio@gmail.com

Address: Office # 01, Devis Road Habibullah Street, Near Durand Rd, Lahore, Pakistan.

THESE DRAWINGS REMAIN THE PROPERTY OF SKART Design Studio ANY REPRODUCTION WILL CONSIDERED TO BE UNLAWFUL. ELECTRICAL CONSULTANT:

SKART DESIGN STUDIO

STRUCTURAL CONSULTANT:

SKART DESIGN STUDIO

PUBLIC HEALTH CONSULTANT:

SKART DESIGN STUDIO

DESIGN PROPOSAL

NOTES:

Designed by: Ar.Tasneem

ID No: A-201 Scale: AS SHOWN DATE: 10-01-2025 REVISED DATE: 00-00-2025 REVISION NO: 00

GROUND FLOOR **PLUMBING** LAYOUT PLAN Original drawing is A3. Scale entities accordingly if reduced Sheet Number:







SKART DESIGN STUDIO

LET'S VISUALISE YOUR DREAM ARCHITECTURE , INTERIOR DESIGN WOOD WORKS Voice: +92 313 5734471

E-mail: Skart.design.studio@gmail.com

Address: Office # 01, Devis Road Habibullah Street, Near Durand Rd, Lahore, Pakistan.

THESE DRAWINGS REMAIN THE PROPERTY OF SKART Design Studio ANY REPRODUCTION WILL CONSIDERED TO BE UNLAWFUL. ELECTRICAL CONSULTANT:

SKART DESIGN STUDIO

STRUCTURAL CONSULTANT:

SKART DESIGN STUDIO

PUBLIC HEALTH CONSULTANT:

SKART DESIGN STUDIO


DESIGN PROPOSAL

NOTES:

Designed by: Ar.Tasneem

ID No: A-201 Scale: AS SHOWN DATE: 10-01-2025 REVISED DATE: 00-00-2025 REVISION NO: 00

FIRST FLOOR PLUMBING LAYOUT PLAN Original drawing is A3. Scale entities accordingly if reduced Sheet Number:

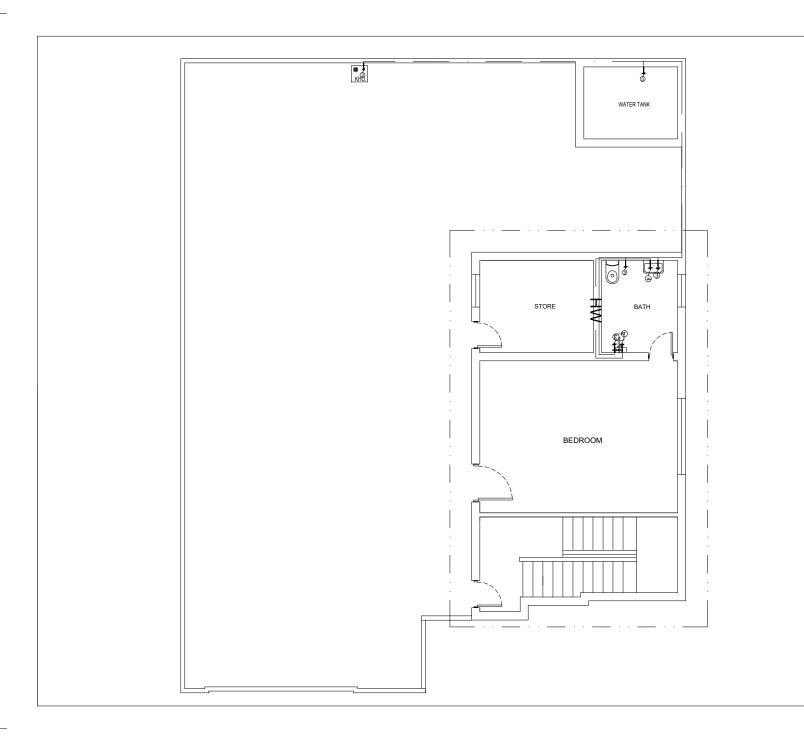

Architecture Plan.



SKART DESIGN STUDIO

LET'S VISUALISE YOUR DREAM ARCHITECTURE, INTERIOR DESIGN WOOD WORKS

Voice: +92 313 5734471

E-mail: Skart.design.studio@gmail.com

Address: Office # 01, Devis Road Habibullah Street, Near Durand Rd, Lahore, Pakistan.

THESE DRAWINGS REMAIN THE PROPERTY OF SKART Design Studio ANY REPRODUCTION WILL CONSIDERED TO BE UNLAWFUL. ELECTRICAL CONSULTANT:

SKART DESIGN STUDIO

STRUCTURAL CONSULTANT:

SKART DESIGN STUDIO

PUBLIC HEALTH CONSULTANT:

SKART DESIGN STUDIO

DESIGN PROPOSAL

NOTES:

Drawn by: Ar.Tasneem Designed by: Ar.Tasneem

ID No: A-201 Scale: AS SHOWN DATE: 10-01-2025 REVISED DATE: 00-00-2025 REVISION NO: 00

MUMTY FLOOR PLUMBING LAYOUT PLAN

Original drawing is A3. Scale entities accordingly if reduced Sheet Number:

PLUMBING LEGEND	
1	U.G W.TANK
2	INSTANT GAZER
3	3/4" DIA G.I COLD WATER PIPE
4	3/4" DIA G.I HOT WATER PIPE
5	FILTER POINT
6	GAS POINT

1 - COLD WATER LINE SHOWN THUS HW -2 -HOT WATER LINE SHOWN THUS – MH -3 - GAS LINE SHOWN THUS GAS - GAS -— GAS ——— GAS —





SKART DESIGN STUDIO

LET'S VISUALISE YOUR DREAM ARCHITECTURE , INTERIOR DESIGN WOOD WORKS Voice: +92 313 5734471

E-mail: Skart.design.studio@gmail.com

Address: Office # 01, Devis Road Habibullah Street, Near Durand Rd, Lahore, Pakistan.

THESE DRAWINGS REMAIN THE PROPERTY OF SKART Design Studio ANY REPRODUCTION WILL CONSIDERED TO BE UNLAWFUL. ELECTRICAL CONSULTANT:

SKART DESIGN STUDIO STRUCTURAL CONSULTANT:

SKART DESIGN STUDIO

PUBLIC HEALTH CONSULTANT:

SKART DESIGN STUDIO

DESIGN

PROPOSAL


NOTES:

Designed by: Ar.Tasneem

ID No: A-201 Scale: AS SHOWN DATE: 10-01-2025 REVISED DATE: 00-00-2025 REVISION NO: 00

LEGEND

Original drawing is A3. Scale entities accordingly if reduced Sheet Number:

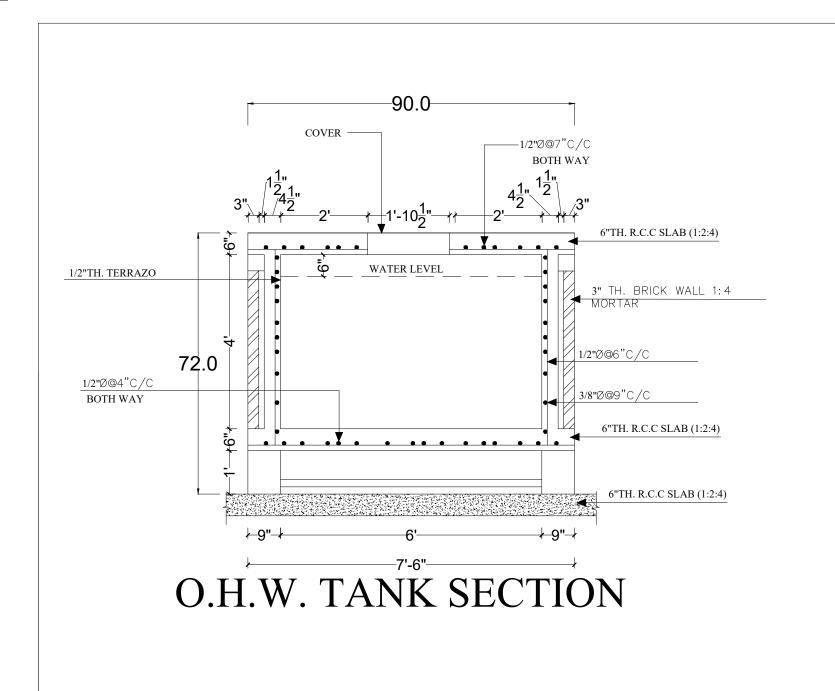





LET'S VISUALISE YOUR DREAM ARCHITECTURE, INTERIOR DESIGN WOOD WORKS Voice: +92 313 5734471

E-mail: Skart.design.studio@gmail.com

Address: Office # 01, Devis Road Habibullah Street, Near Durand Rd, Lahore, Pakistan.

THESE DRAWINGS REMAIN THE PROPERTY OF SKART DESIGN S
ANY REPRODUCTION WILL CONSIDERED TO BE UNLAWFUL.

ELECTRICAL CONSULTANT:

SKART DESIGN STUDIO

STRUCTURAL CONSULTANT:

SKART DESIGN STUDIO

PUBLIC HEALTH CONSULTANT:

SKART DESIGN STUDIO

DESIGN PROPOSAL

NOTES

SKART DESIGN STUDIO DOES NOT PROVIDE A

AND FOUNDATION ON SITE.

PLAN FOR EXCAVATION AND FOUNDATION ON-

SKART DESIGN STUDIO ONLY PROVIDES THE

FOR STARTING CONSTRUCTION WORK ON SITE

SKART DESIGN STUDIO WILL NOT BE

RESPONSIBLE IN CASE OF ANY VARIATION OF

IN CASE OF ANY KIND OF MISTAKE OR DIFF

IN SIZES IN THE FOUNDATION AND EXCAVAT

DURING CONSTRUCTION, THE SITE WILL NOT BE APPROVED BY THE ARCHITECT.

Designed by: Ar.Tasneem

ID No: A-201
Scale: AS SHOWN
DATE: 10-01-2025
REVISED DATE: 00-00-202
REVISION NO: 00

Sheet Title

O.H.W. TANK SECTION

Original drawing is A3. Scale entities accordingly if reduced Sheet Number:

STEL LAYOUT DRAWINGS

PROJECT TITLE: Mr. MUSTAFA Residential

Architecture Plan.



SKART DESIGN STUDIO

LET'S VISUALISE YOUR DREAM ARCHITECTURE, INTERIOR DESIGN

Voice: +92 313 5734471

F-mail: Skart.design.studio@gmail.com

Address: Office # 01, Devis Road Habibullah Street. lear Durand Rd. Lahore.

THESE DRAWINGS REMAIN THE PROPERTY OF SKART Design Studio ANY REPRODUCTION WILL CONSIDERED TO BE UNLAWFUL.

ELECTRICAL CONSULTANT:

SKART DESIGN STUDIO

STRUCTURAL CONSULTANT:

SKART DESIGN STUDIO

PUBLIC HEALTH CONSULTANT:

SKART DESIGN STUDIO

DESIGN PROPOSAL

NOTES:

Drawn by: Ar.Tasneem Designed by: Ar. Tasneem

ID No: A-201 Scale: AS SHOWN DATE: 10-01-2025 REVISED DATE: 00-00-2025

TITLE PAGE PLUMBING LAYOUT PLAN

Original drawing is A3. Scale entities accordingly if reduced

STRUCTURE LAYOUT DRAWINGS

PROJECT TITLE:
Mr. MUSTAFA
Residential

Architecture Plan.



SKART DESIGN STUDIO

LET'S VISUALISE YOUR DREAM ARCHITECTURE, INTERIOR DESIGN

> Voice: +92 313 5734471

E-mail: Skart.design.studio@gmail.com

Address: Office # 01, Devis Road Habibullah Street, Near Durand Rd, Lahore, Pakistan

THESE DRAWINGS REMAIN THE PROPERTY OF SKART Design Studios any reproduction will considered to be unlawful.

ELECTRICAL CONSULTANT:

SKART DESIGN STUDIO

STRUCTURAL CONSULTANT:

SKART DESIGN STUDIO

PUBLIC HEALTH CONSULTANT:

SKART DESIGN STUDIO

DESIGN PROPOSAL

NOTES:

CART DESIGN STUDIO DOES NOT PROVIDE A

AND FOUNDATION ON SITE.

 SKART DESIGN STUDIO ISSUED A GROUND FLOO PLAN FOR EXCAVATION AND FOUNDATION ON-SIT

SKART DESIGN STUDIO ONLY PROVIDES THE

EXCAVATION AND FOUNDATION DETAILED PI FOR STARTING CONSTRUCTION WORK ON SIT

SKART DESIGN STUDIO WILL NOT BE

RESPONSIBLE IN CASE OF ANY VARIATION OF

IN CASE OF ANY KIND OF MISTAKE OR DIFF
 IN SIZES IN THE FOUNDATION AND EXCAVA


DURING CONSTRUCTION, THE SITE WILL NO APPROVED BY THE ARCHITECT.

Drawn by: Ar.Tasneem
Designed by: Ar.Tasneem

ID No: A-201 Scale: AS SHOWN DATE: 10-01-2025 REVISED DATE: 00-00-2025 REVISION NO: 00

Shee

TITLE PAGE
STRUCTURE
LAYOUT PLAN
Original drawing is A3. Scale entities accordingly 1' reduced
Smell Numbers.

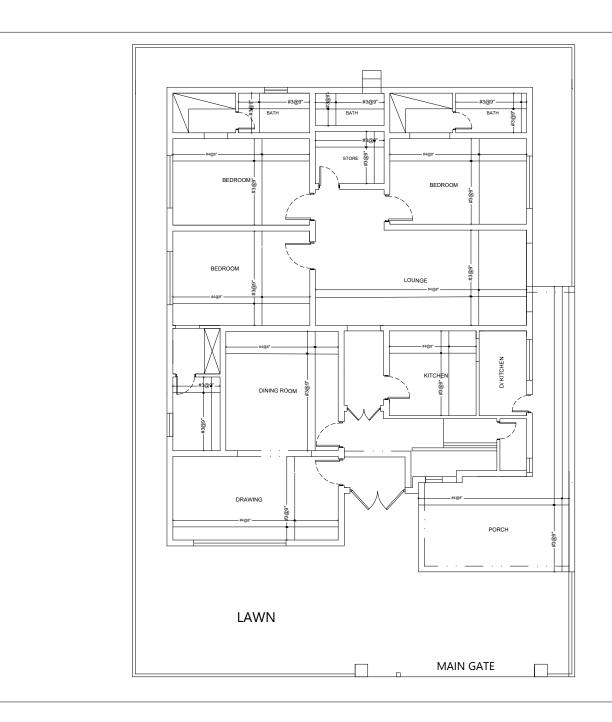

PROJECT TITLE: Mr. MUSTAFA Residential Architecture Plan.



SKART DESIGN STUDIO

LET'S VISUALISE YOUR DREAM ARCHITECTURE , INTERIOR DESIGN WOOD WORKS

Voice: +92 313 5734471

E-mail: Skart.design.studio@gmail.com

Address: Office # 01, Devis Road Habibullah Street, Near Durand Rd, Lahore, Pakistan.

THESE DRAWINGS REMAIN THE PROPERTY OF SKART Design Studio ANY REPRODUCTION WILL CONSIDERED TO BE UNLAWFUL. ELECTRICAL CONSULTANT:

SKART DESIGN STUDIO

STRUCTURAL CONSULTANT:

SKART DESIGN STUDIO

PUBLIC HEALTH CONSULTANT:

SKART DESIGN STUDIO

DESIGN PROPOSAL

NOTES:


Drawn by: Ar.Tasneem

Designed by: Ar.Tasneem

ID No: A-201 Scale: AS SHOWN DATE: 10-01-2025 REVISED DATE: 00-00-2025 REVISION NO: 00

GROUND FLOOR STEEL PLAN.

Original drawing is A3. Scale entities accordingly if reduced Sheet Number:

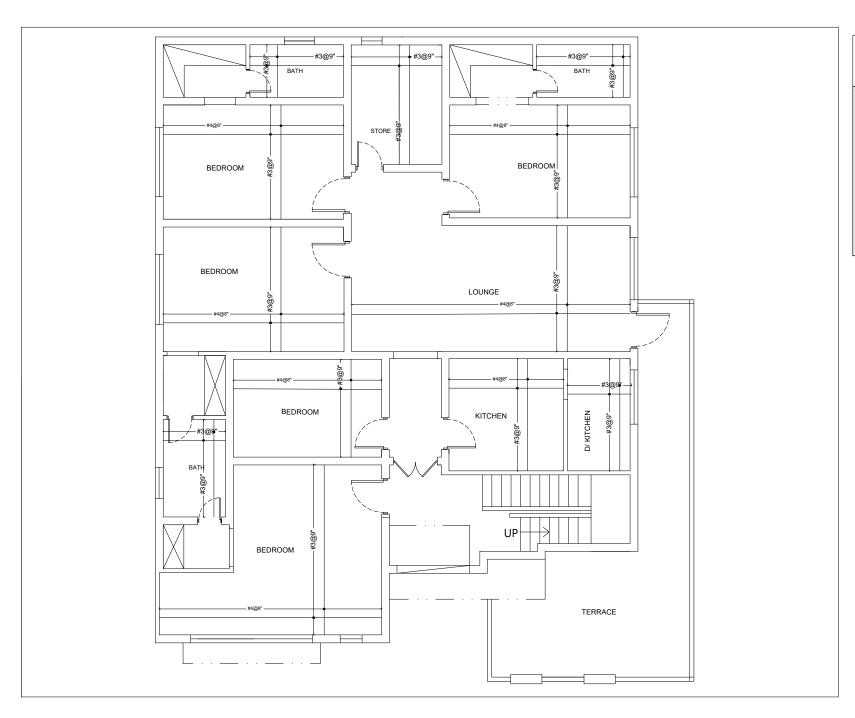

Residential Architecture Plan.



SKART DESIGN STUDIO

LET'S VISUALISE YOUR DREAM ARCHITECTURE, INTERIOR DESIGN WOOD WORKS

Voice: +92 313 5734471

E-mail: Skart.design.studio@gmail.com

Address: Office # 01, Devis Road Habibullah Street, Near Durand Rd, Lahore, Pakistan.

THESE DRAWINGS REMAIN THE PROPERTY OF SKART Design Studio ANY REPRODUCTION WILL CONSIDERED TO BE UNLAWFUL.

ELECTRICAL CONSULTANT:

SKART DESIGN STUDIO

STRUCTURAL CONSULTANT:

SKART DESIGN STUDIO

PUBLIC HEALTH CONSULTANT:

SKART DESIGN STUDIO

DESIGN PROPOSAL

NOTES:

SKART DESIGN STUDIO DOES NOT PROVIDE A

GROUND FLOOR LAYOUT PLAN FOR EXCAVATION AND FOUNDATION ON SITE.

PLAN FOR EXCAVATION AND FOUNDATION ON-S

SKART DESIGN STUDIO ONLY PROVIDES THE

FOR STARTING CONSTRUCTION WORK ON SIT

 SKART DESIGN STUDIO WILL NOT BE RESPONSIBLE IN CASE OF ANY VARIATION OF

MISTAKE ON-SITE AT THE TIME OF CONSTRU

IN CASE OF ANY KIND OF MISTAKE OR DIFFER

IN SIZES IN THE FOUNDATION AND EXCAVATION PROPERTY OF THE SIZE WILL MOST BE

DURING CONSTRUCTION, THE SITE WILL NOT BE APPROVED BY THE ARCHITECT.


Drawn by: Ar.Tasneem
Designed by: Ar.Tasneem

ID No: A-201 Scale: AS SHOWN DATE: 10-01-2025 REVISED DATE: 00-00-2025 REVISION NO: 00

Sheet Title

FIRST FLOOR STEEL PLAN

Original drawing is A3. Scale entities accordingly if reduced Sheet Number:

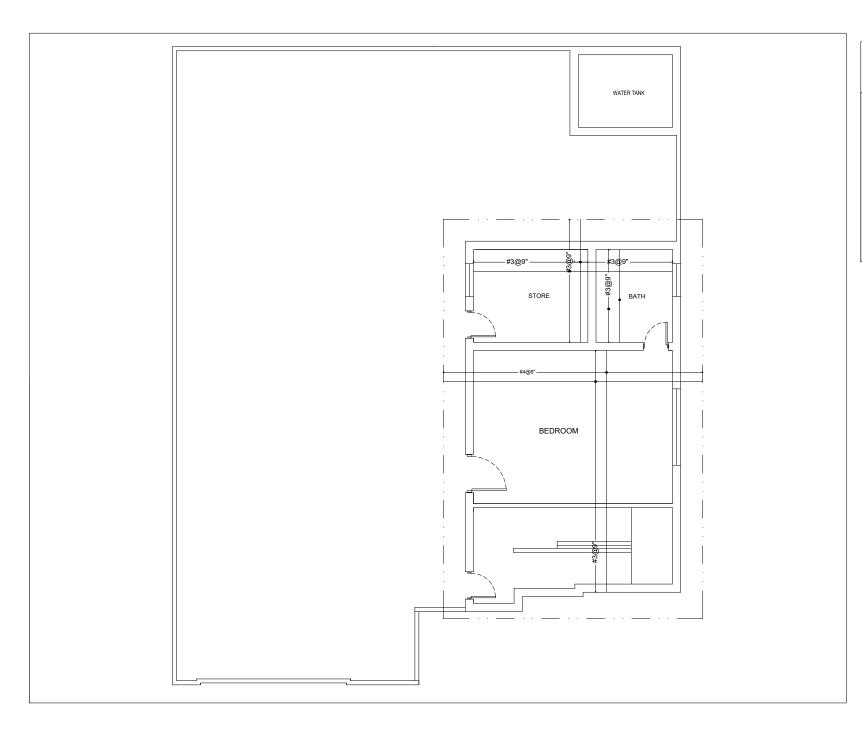

Architecture Plan.



SKART DESIGN STUDIO

LET'S VISUALISE YOUR DREAM ARCHITECTURE, INTERIOR DESIGN WOOD WORKS

Voice: +92 313 5734471

E-mail: Skart.design.studio@gmail.com

Address: Office # 01, Devis Road Habibullah Street, Near Durand Rd, Lahore, Pakistan.

THESE DRAWINGS REMAIN THE PROPERTY OF SKART Design Studio ANY REPRODUCTION WILL CONSIDERED TO BE UNLAWFUL. ELECTRICAL CONSULTANT:

SKART DESIGN STUDIO STRUCTURAL CONSULTANT:

SKART DESIGN STUDIO

PUBLIC HEALTH CONSULTANT:

SKART DESIGN STUDIO

DESIGN PROPOSAL

NOTES:


Drawn by: Ar.Tasneem

Designed by: Ar.Tasneem

ID No: A-201 Scale: AS SHOWN DATE: 10-01-2025 REVISED DATE: 00-00-2025 REVISION NO: 00

MUMTY FLOOR STEEL PLAN

Original drawing is A3. Scale entitles accordingly if reduced Sheet Number:

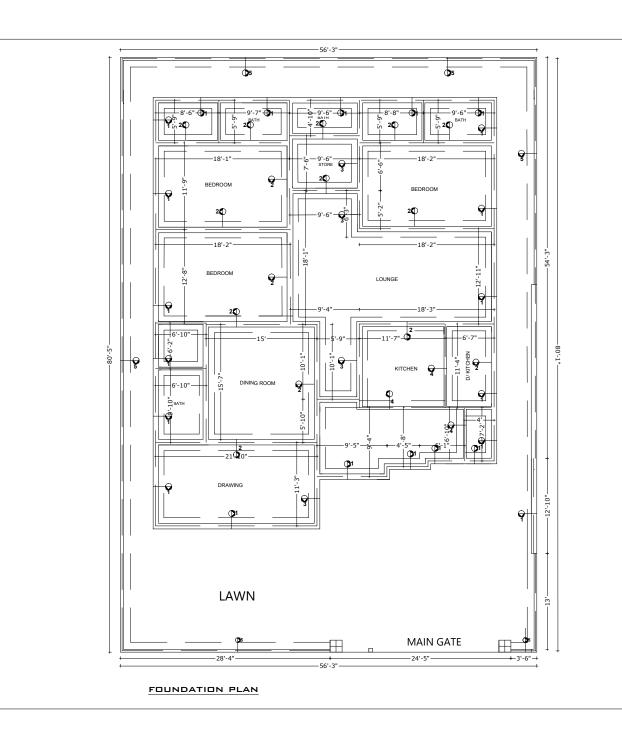





LET'S VISUALISE YOUR DREAM ARCHITECTURE, INTERIOR DESIGN WOOD WORKS

Voice: +92 313 5734471 E-mail: Skart.design.studio@gmail.com

Address: Office # 01, Devis Road Habibullah Street, Near Durand Rd, Lahore, Pakistan.

THESE DRAWINGS REMAIN THE PROPERTY OF SKART Design Studio ANY REPRODUCTION WILL CONSIDERED TO BE UNLAWFUL.

ELECTRICAL CONSULTANT:

SKART DESIGN STUDIO

STRUCTURAL CONSULTANT:

SKART DESIGN STUDIO

PUBLIC HEALTH CONSULTANT:

SKART DESIGN STUDIO

DESIGN PROPOSAL

NOTES:

SKART DESIGN STUDIO DOES NOT PROVIDE A

AND FOUNDATION ON SITE.

PLAN FOR EXCAVATION AND FOUNDATION ON-SI

SKART DESIGN STUDIO ONLY PROVIDES TH

FOR STARTING CONSTRUCTION WORK ON SIT

 SKART DESIGN STUDIO WILL NOT BE RESPONSIBLE IN CASE OF ANY VARIATION (

IN CASE OF ANY KIND OF MISTAKE OR DIFFER

IN SIZES IN THE FOUNDATION AND EXCAVATIO

DURING CONSTRUCTION, THE SITE WILL NOT B APPROVED BY THE ARCHITECT.

Designed by: Ar.Tasneem

ID No: A-201 Scale: AS SHOWN DATE: 10-01-2025 REVISED DATE: 00-00-2025 REVISION NO: 00

Sheet Titl

FOUNDATION PLAN


Original drawing is A3. Scale entitles accordingly if reduced Sheet Number:




- 1- DAMP PROOF COURSE (D.P.C)
- 2- NATURAL SOIL LEVEL (N.S.L)

(R.L)

- 3- ROAD LEVEL
- 4- FINISH FLOOR LEVEL (F.F.L)
- 5- SIDE PASSAGE LEVEL (S.P.L)

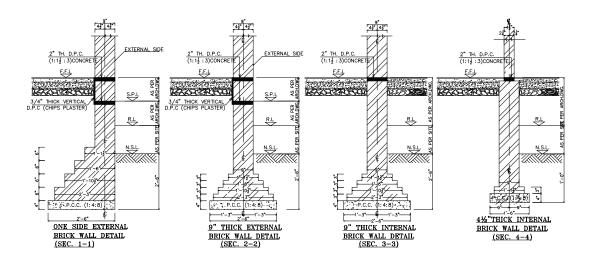

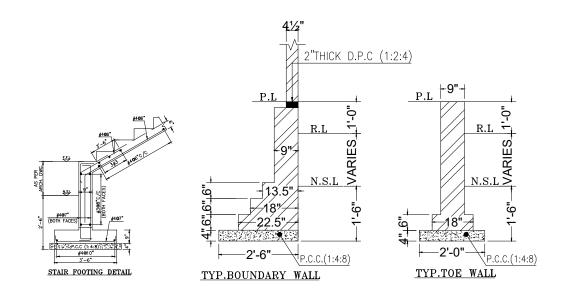

PROJECT TITLE:

Mr. MUSTAFA Residential

Architecture Plan.



SKART DESIGN STUDIO

LET'S VISUALISE YOUR DREAM ARCHITECTURE, INTERIOR DESIGN WOOD WORKS

Voice: +92 313 5734471

E-mail: Skart.design.studio@gmail.com

Address: Office # 01, Devis Road Habibullah Street, Near Durand Rd, Lahore, Pakistan.

THESE DRAWINGS REMAIN THE PROPERTY OF SKART Design :
ANY REPRODUCTION WILL CONSIDERED TO BE UNLAWFUL. ELECTRICAL CONSULTANT:

SKART DESIGN STUDIO

STRUCTURAL CONSULTANT:

SKART DESIGN STUDIO

PUBLIC HEALTH CONSULTANT:

SKART DESIGN STUDIO

DESIGN PROPOSAL

NOTES:

Designed by: Ar.Tasneem

ID No: Scale: DATE: A-201 AS SHOWN 10-01-2025

FOUNDATION DETAIL.

Original drawing is A3. Scale entities accordingly if reduced Sheet Number:

NOTES:

GRADF 40

- 1- ALL REINFORCED CONCRETE SHALL HAVE MINIMUM CUBE STRENGTH 3750 Psi AT 28 DAYS FOR COLUMNS (CONCRETE MIX 1:1.5:3) AND 3000 Psi AT 28 DAYS FOR ALL OTHER RCC MEMBERS (CONCRETE MIX 1:2:4)
- 2- USE LAWRENCEPUR & CHENAB SAND WITH (50:50) RATIO IN ALL STRUCTURAL CONCRETE WORKS.
- 3- USE CHENAB SAND IN ALL PLASTERING WORKS.
- 4- ALL REINFORCING STEEL EXCEPT TIES (#3) OF BEAMS/COLUMNS SHALL BE CONFORMING TO ASTM A615 GRADE 60 DEFORM STEEL. TIES(#3) OF BEAMS AND COLUMNS SHALL BE CONFORMING TO ASTM A615
- 5- CONCRETE COVER TO REINFORCEMENT SHALL BE AS FOLLOWS.
 - (i) FOUNDATIONS = 2 INCH
 - (ii) COLUMNS = 1½ INCH
 - (iii) SLABS = 3/4 INCH
 - (iv) BEAM (BOTTOM)= 11/2 INCH, (SIDES)=1 INCH
- 6- LAP LENGTH SHALL BE 48 TIMES DIAMETER OF SMALLER BAR.
- 7- PROVIDE HOLDINGS BARS #3@12" TO HOLD THE TOP BARS OF SLAB.
- 8- ALL LEVELS, DIMENSION & DETAIL TO BE VERIFIED FROM ARCHTECTURAL DRAWINGS BEFORE CONSTRUCTION.
- 9- ALL CONCRETE USE SHALL BE MACHINE MIX NOT HAND MIXING IS ALLOWED IN CONCRETE.



SKART DESIGN STUDIO LET'S VISUALISE YOUR DREAM

> ARCHITECTURE , INTERIOR DESIGN WOOD WORKS Voice: +92 313 5734471

Skart.design.studio@gmail.com

Address: Office # 01, Devis Road Habibullah Street. ear Durand Rd. Lahore

ELECTRICAL CONSULTANT:

SKART DESIGN STUDIO

STRUCTURAL CONSULTANT:

SKART DESIGN STUDIO PUBLIC HEALTH CONSULTANT

SKART DESIGN STUDIO


DESIGN PROPOSAL

Designed by: Ar. Tasneem

10-01-2025

NOTES.

Original drawing is A3. Scale entities accordingly if reduces

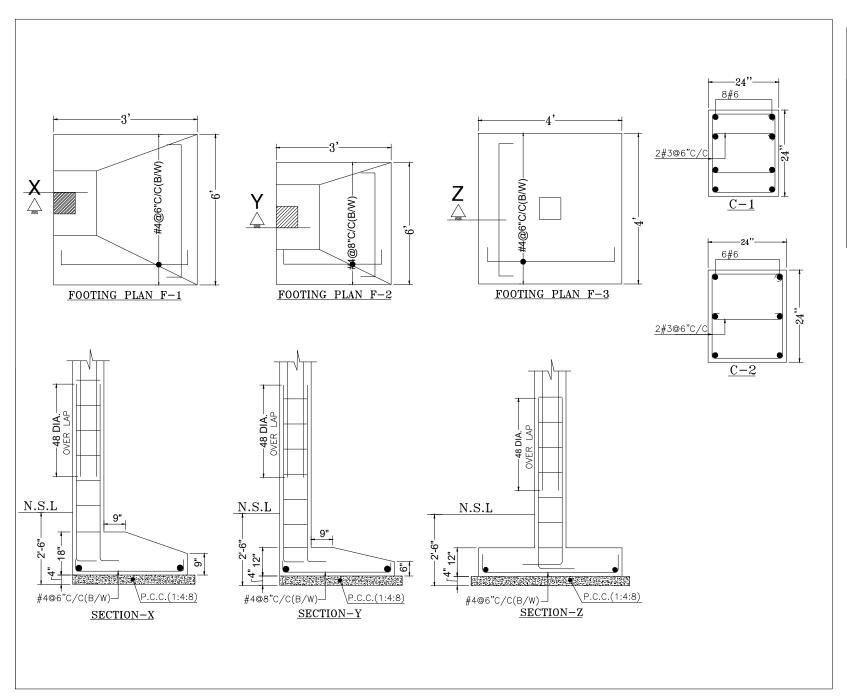





SKART DESIGN STUDIO LET'S VISUALISE YOUR DREAM

ARCHITECTURE , INTERIOR DESIGN WOOD WORKS Voice: +92 313 5734471

E-mail: Skart.design.studio@gmail.com

Address: Office # 01, Devis Road Habibullah Street, Near Durand Rd, Lahore, Pakistan.

THESE DRAWINGS REMAIN THE PROPERTY OF SKART Design Studio ANY REPRODUCTION WILL CONSIDERED TO BE UNLAWFUL. ELECTRICAL CONSULTANT:

SKART DESIGN STUDIO

STRUCTURAL CONSULTANT:

SKART DESIGN STUDIO

PUBLIC HEALTH CONSULTANT:

SKART DESIGN STUDIO

DESIGN PROPOSAL

NOTES:

Designed by: Ar Tasneem

ID No: Scale: DATE: A-201 AS SHOWN 10-01-2025 REVISED DATE: 00-00-2025 REVISION NO: 00

FOOTING APLAN.

Original drawing is A3. Scale entities accordingly if reduced Sheet Number: